

## 6QA-01 ELECTRICAL NOTES

### POWER RECEPTACLE PEDESTAL

EQUAL TO SQUARE D #PAK 13P 60 INCH HIGH RAINPROOF PEDESTAL SET 25 INCHES IN THE GROUND AND CONCRETE ENCASED BELOW GRADE. PROVIDE A 30 AMPERE RECEPTACLE WITH A 30 AMPERE, 1 POLE GFI BREAKER. INCLUDE PROVISION FOR PADLOCKING. SEE LANDSCAPE ARCHITECTURE DRAWING 6F FOR LOCATION ADJACENT TO FLAGPOLE.

### FLAGPOLE AND AREA LIGHTING

EXTEND 1/2" CONDUIT BELOW FLAGPOLE FOUNDATION AND ENTER FROM BOTTOM (48" BELOW GRADE). EXTEND TO 45" ABOVE GRADE. MOUNT LIGHTS 10' ABOVE GRADE AS PER MANUFACTURER'S RECOMMENDATIONS. UTILIZE WINCH ENTRY FOR ACCESS.

### TELEPHONE OUTLET MOUNTING HEIGHT

VERIFY TELEPHONE MOUNTING HEIGHT WITH LOCAL TELEPHONE COMPANY AND COORDINATE WITH TILE CONTRACTOR.

### INSTALLATION OF ELECTRIC OUTLET BOXES AND CONDUIT


CONDUITS SHALL BE CONCEALED IN ALL AREAS EXCEPT ROOMS 104, 105, AND 108 WHERE CONDUITS AND DEVICES SHALL BE SURFACE MOUNTED.

### DOOR SECURITY SWITCH - RM. 101, DDS-2


FURNISH & INSTALL EDWARDS NO. 502 DOOR SW. IN DOOR JAMB CUTOUT. EXTEND 1/2" CONDUIT TO SECURITY PANEL. USE 1/2" FLEXIBLE CONDUIT FOR CONNECTION TO JAMB SWITCH. ROUTED TO J.B. ABOVE CLG.

### RAMP & PICNIC AREA LIGHTING


ALL RAMP & PICNIC AREA LIGHTING SHALL BE WIRED FOR 120/240 VOLT, 3-WIRE GROUNDED NEUTRAL CONNECTIONS. EXISTING LUMINAIRES WHICH ARE FOUND TO BE WIRED FOR 480 VOLTS SHALL BE REMOVED AND TURNED OVER TO AND REMAIN THE PROPERTY OF THE DISTRICT OFFICE OF THE OHIO DEPARTMENT OF TRANSPORTATION. THE 480 VOLT LUMINAIRES SHALL BE REPLACED IN LIKE KIND EXCEPT THEY SHALL BE FURNISHED W/240 VOLT BALLASTS AND WIRED FOR 120/240 VOLT, 3-WIRE GROUNDED NEUTRAL IN ACCORDANCE WITH 713.11.

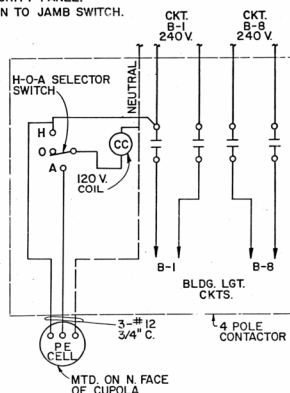


PE CONTROLLED  
BLDG. LGT. CKTS.  
NOT TO SCALE  
6QA-05

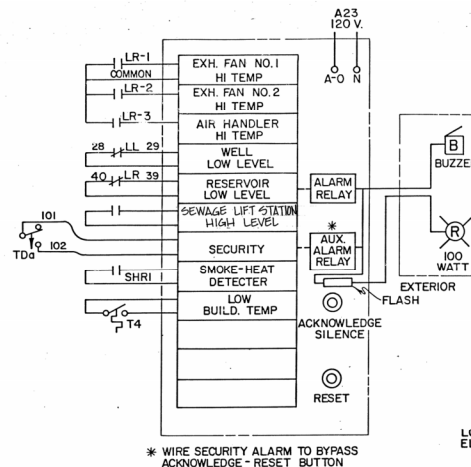

ALARM ANNUNCIATOR PANEL  
NOT TO SCALE  
6QA-02

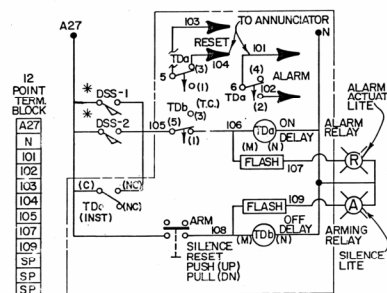

SECURITY PANEL  
NOT TO SCALE  
6QA-03

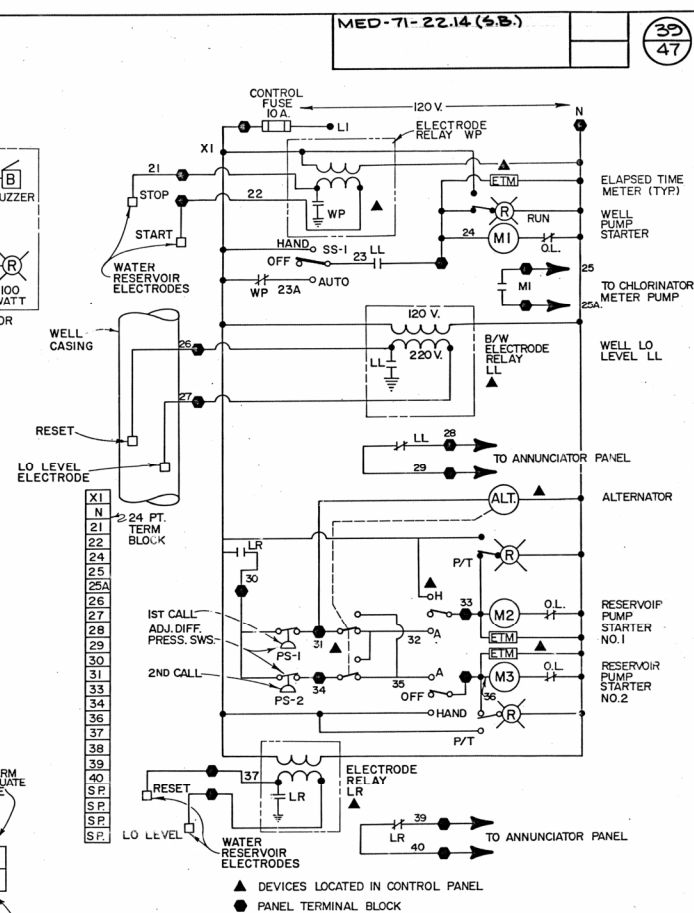

WELL RESERVOIR CONTROL PANEL  
NOT TO SCALE  
6QA-04

| OHIO DEPARTMENT OF TRANSPORTATION<br>DIVISION OF HIGHWAYS                                                                                                                                             |                                                    |                  |
|-------------------------------------------------------------------------------------------------------------------------------------------------------------------------------------------------------|----------------------------------------------------|------------------|
| REVISIONS<br>8-3-84<br>11-1-84<br>1-28-85                                                                                                                                                             | MOTORIST SERVICES BUILDING<br>AND<br>STORAGE UNITS | SHEET NO.<br>6QA |
| ARCHITECTS: WRIGHT KRITZSCHAU ASSOCIATES, INC.<br>3600 TRABUE RD., COLUMBUS, OHIO<br>ENGINEERS: JOHN E. FOSTER & ASSOCIATES, COLUMBUS, OHIO<br>ENERGY TECHNOLOGIES - BATTELLE / COLUMBUS LABORATORIES |                                                    | DATL             |

## PANEL "A" LITE SCHEDULE

## PANEL "B" LITE SCHEDULE


225 AMP 42 POLE 120/240 VOLT 1 PHASE 60 HERTZ 3 WIRE S/N W/MAIN LUGS ONLY

100 AMP 20 POLE 120/240 VOLT 1 PHASE 60 HERTZ 3 WIRE S/N W/MAIN LUGS ONLY


| CIRCUIT NO. | PANEL POSITION | BREAKER POLES/AMPS | DESCRIPTION                | LOCATION         | VOLTS | HP/FLA | WIRE SIZE | CONDUIT SIZE | CONNECTED WATTAGE | REMARKS                   |
|-------------|----------------|--------------------|----------------------------|------------------|-------|--------|-----------|--------------|-------------------|---------------------------|
| 1           | 1-3            | 2-20               | SPARE                      |                  | 240   |        |           |              |                   |                           |
| 2           | 2-4            | 2-60               | RAMP-AREA LITES            | RM 105           | 240   | 41.5   | 6         | 1            | 10,000            | CONTROL CONTACTOR         |
| 3           | 5-7            | 2-20               | SPARE                      |                  | 240   |        |           |              |                   |                           |
| 4           | 6-8            | 2-20               | SPARE                      |                  | 240   |        |           |              |                   |                           |
| 5           | 9              | 1-20               | EXH. FAN #1                | 104              | 120   | 8.5    | 12        | 3/4"         | 720               | TO H & V PANEL            |
| 6           | 10             | 1-20               | EXH. FAN #2                | 108              | 120   | 8.5    | 12        | 3/4"         | 720               | TO H & V PANEL            |
| 7           | 11             | 1-20               | DAMPER                     | 105              | 120V  | .5     | 12        | 3/4"         | 60                | TO H & V PANEL            |
| 8           | 12             | 1-30               | BLOWER                     | 105              | 120V  | 20     | 10        | 3/4"         | 2400              | TO H & V PANEL            |
| 9           | 13-15          | 2-20               | HAND DRYER                 | RM 103           | 240   | 10     | 12        | 3/4          | 2400              | *                         |
| 10          | 14-16          | 2-20               | HAND DRYER                 | RM 107           | 240   | 10     | 12        | 3/4          | 2400              | *                         |
| 11          | 17             | 1-20               | CHLORINATOR                | RM 105           | 120   | 5.8    | 12        | 3/4          | 700               |                           |
| 12          | 18             | 1-20               | SPARE                      |                  | 120   |        |           |              |                   |                           |
| 13          | 19             | 1-20               | CHILLER                    | RM 104           | 120   | 5.3    | 12        | 3/4          | 630               | * FOR WATER FOUNTAIN      |
| 14          | 20             | 1-20               | SPARE                      |                  | 120   |        |           |              |                   |                           |
| 15          | 21             | 1-20               | RECEPTACLE                 | RM 102, 103, 104 | 120   | 8.3    | 12        | 3/4          | 1000              | * GFI BREAKER             |
| 16          | 22             | 1-20               | RECEPTACLE                 | RM 105, 102, 108 | 120   | 8.3    | 12        | 3/4          | 1000              | * GFI BREAKER             |
| 17          | 23             | 1-20               | RECEPTACLE, DOOR           | RM 105           | 120   | 8.3    | 12        | 3/4          | 1000              | GFI BREAKER               |
| 18          | 24             | 1-20               | RECEPTACLE                 | RM 101           | 120   | 8.3    | 12        | 3/4          | 1000              |                           |
| 19          | 25-27          | 2-20               | HAND DRYER                 | RM 102           | 240   | 10     | 12        | 3/4          | 2400              | *                         |
| 20          | 26-28          | 2-20               | HAND DRYER                 | RM 106           | 240   | 10     | 12        | 3/4          | 2400              | *                         |
| 21          | 29-31          | 2-20               | HAND DRYER                 | RM 102           | 240   | 10     | 12        | 3/4          | 2400              | *                         |
| 22          | 30-32          | 2-20               | HAND DRYER                 | RM 106           | 240   | 10     | 12        | 3/4          | 2400              | *                         |
| 23          | 33             | 1-20               | SMOKE DETECTOR             | RM 105           | 120   | 3      | 12        | 3/4          | 360               |                           |
| 24          | 34             | 1-30               | RECEPTACLE                 | RM 101           | 120   | 8.3    | 10        | 3/4          | 1000              |                           |
| 25          | 35             | 1-30               | RECEPTACLE, POWER PEDESTAL | EXTERIOR         | 120   | 13.3   | 10        | 3/4          | 1600              | GFI BREAKER AT RECEPTACLE |
| 26          | 36             | 1-15               | SPARE                      |                  | 120   |        |           |              |                   |                           |
| 27          | 37-39          | 2-30               | SPARE                      |                  | 240   |        |           |              |                   |                           |
| 28          | 38-40          | 2-30               | SPARE                      |                  | 240   |        |           |              |                   |                           |
| 29          | 41-42          | 2-30               | SPARE                      |                  | 240   |        |           |              |                   |                           |

\* DENOTES CKTS. ROUTED IN RESTROOM SERVICE RACEWAYS

TOTAL CONNECTED WATTS 36,590

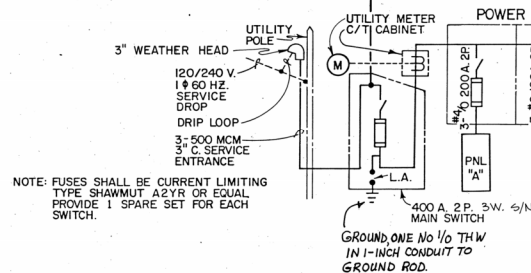


POWER PANEL "P" 400 A, 120/240 V, 3 WIRE, 60 HZ, S/N W/MAIN LUGS

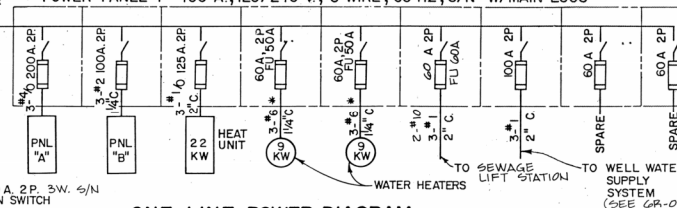

ONE LINE POWER DIAGRAM

NOTE: FURNISH AND INSTALL ALL BREAKERS, SIZE AND POLES AS SHOWN FOR ALL PANELS.

TOTAL CONNECTED WATTS 6610

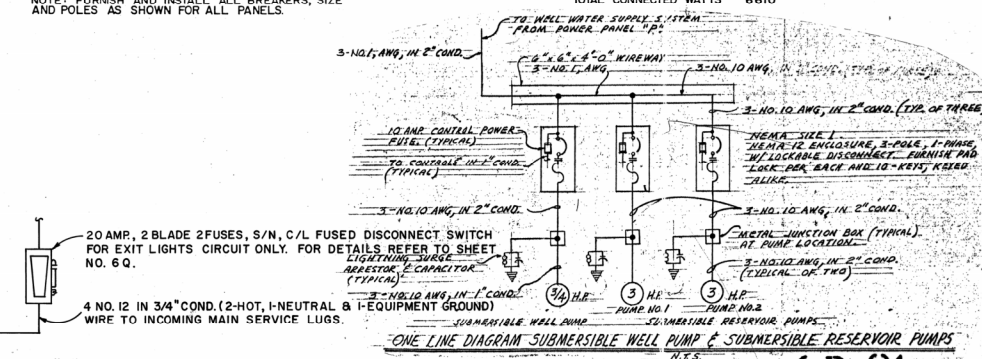


6R-01

OHIO DEPARTMENT OF TRANSPORTATION  
DIVISION OF HIGHWAYSREVISIONS  
10-24-84  
11-23-84  
1-28-85MOTORIST SERVICES BUILDING  
AND  
STORAGE UNITSSHEET NO  
6RARCHITECTS: WRIGHT/KRITSCHGALL ASSOCIATES, INC.  
3600 TRABUE RD., COLUMBUS, OHIO  
ENGINEERS: JOHN E. FOSTER & ASSOCIATES, COLUMBUS, OHIO  
ENERGY TECHNOLOGIES BATTELLE/COLUMBUS LABORATORIES


DATE



COVER SHALL BE NEENAH POUNDRY R-4055 OR EAST JORDAN 6300 OR APPROVED EQUAL

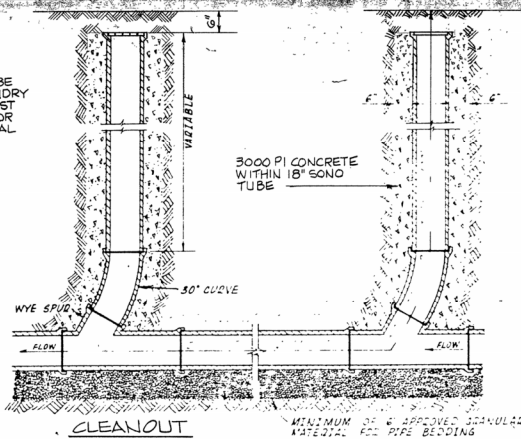

BELL HOLES TO BE EXCAVATED AT EACH JOINT TO INSURE PROPER BEDDING OF PIPE

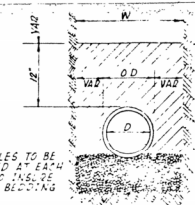


TYPICAL TRENCH SECTION  
SCALE: 1"=1'-0"

| PIPE SIZE | MAX. TRENCH DEPTH | PIPE SIZE | MAX. TRENCH WIDTH |
|-----------|-------------------|-----------|-------------------|
| 8"        | 3'-0"             | 60"       | 8'-0"             |
| 10"       | 3'-6"             | 72"       | 8'-6"             |
| 12"       | 4'-0"             | 84"       | 9'-0"             |
| 15"       | 4'-6"             | 96"       | 10'-0"            |
| 18"       | 5'-0"             | 108"      | 11'-0"            |
| 21"       | 5'-6"             | 120"      | 12'-0"            |
| 24"       | 6'-0"             | 132"      | 13'-0"            |
| 30"       | 7'-0"             | 144"      | 14'-0"            |

THIS STANDARD IS FOR VITRIFIED PIPE SANITARY SEWERS IN UNPAVED AREAS ONLY. SEE GENERAL NOTES FOR ABS & PVC TRENCH CONDITIONS.

 
BELL HOLES



BELL HOLES TO BE EXCAVATED TO INSURE PROPER BEDDING OF PIPE

MINIMUM OF 6" APPROVED GRANULAR MATERIAL FOR PIPE BEDDING


WYE DETAIL  
SCALE: 1"=1'-0"

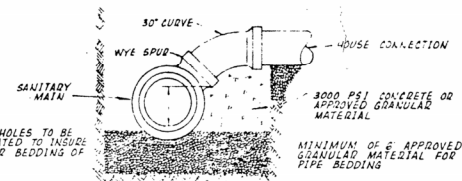


BELL HOLES TO BE EXCAVATED TO INSURE PROPER BEDDING OF PIPE

MINIMUM OF 6" APPROVED GRANULAR MATERIAL FOR PIPE BEDDING

MANHOLE COVER & FRAME  
SCALE: 1"=1'-0"

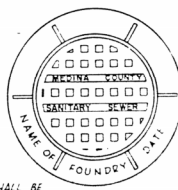

 
MANHOLE FRAME SHALL BE NEENAH POUNDRY R-4055 OR EAST JORDAN 6300 OR APPROVED EQUAL



STANDARD SANITARY MANHOLE  
SCALE: 1"=1'-0"


NOTE: 4 FOOT PIPE SECTIONS MUST CONNECT INTO MANHOLE

ALTERNATE MANHOLE BASE  
SCALE: 1"=1'-0"

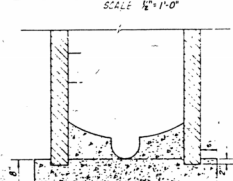

NOTE: IF BOTTOM SECTION AND MANHOLE BASE ARE NOT MONOLITHICALLY CAST AND TIED WITH #5 RE-BARS, THIS BASE IS REQUIRED.

STRAW BALE DIKE

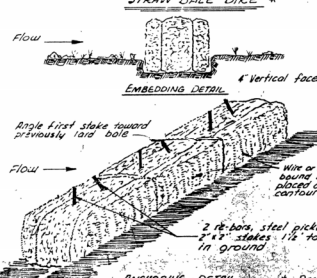


Construction Specifications:  
1. Bales shall be placed in a row with ends tightly butting the adjacent bales.  
2. Each Bale shall be embedded in the soil a minimum of 6".  
3. Bales shall be securely anchored in place by stakes or re-bars driven through the bales. The first stake in each bale shall be angled toward the previously laid bale to force bales together.  
4. Inspection shall be frequent and repair or replacement shall be made promptly as needed when they have served their usefulness so as not to block or impede storm flow or drainage.  
Drainage area less than 15 acres.


MEDINA COUNTY  
MED-71-22.54 (S.B.)  
IR-71-4 (67) 224 PART II

| REGION | STATE | PROJECT      |
|--------|-------|--------------|
| 5      | OHIO  | MED-71-22.54 |

BACKFILL AND COMPACT SOIL IN 6 LAYERS TO A WEIGHT OF 12" ABOVE 90° CURVE

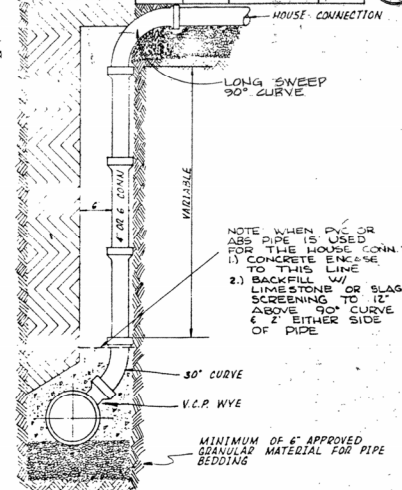

TYPICAL RISER  
SCALE: 1"=1'-0"

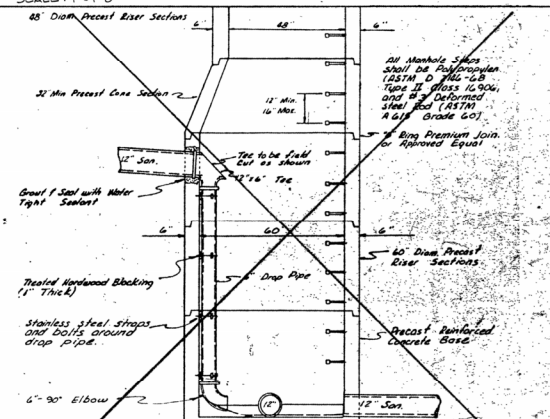

DELETE  
INSIDE SANITARY DROP MANHOLE  
(Scale: 1"=1'-0")

MEDINA COUNTY SANITARY ENGINEERS  
STANDARD DETAIL SHEET


SANITARY SEWER DETAILS

SCALES AS SHOWN  
REVISION: MARCH, 1981  
ADD: (1982) NEW 8" & 10" RISE AND RISE  
DETAIL

PROJECT NO. SHEET NO.

MARCH, 1981

NO.

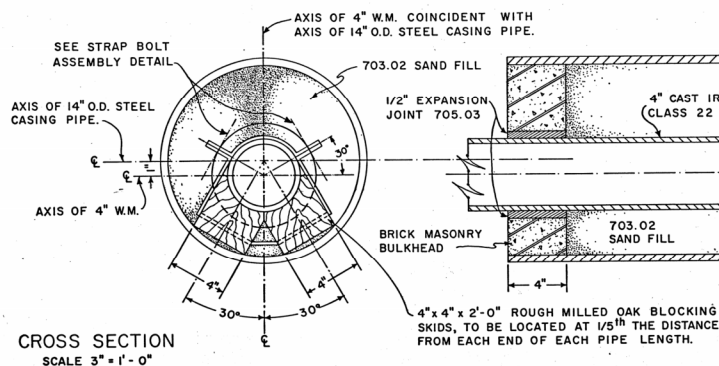


14" O.D. STEEL CASING PIPE A.S.T.M. A-53  
GRADE B, WALL THICKNESS 0.438.

4" CAST IRON PIPE A.S.A.  
CLASS 22 PUSH-ON JOINTS.

1/4" x 2" STEEL STRAP (GALV.)

4" x 4" OAK BLOCKING SKIDS.

LONGITUDINAL ELEVATION  
SCALE 3" = 1'-0"

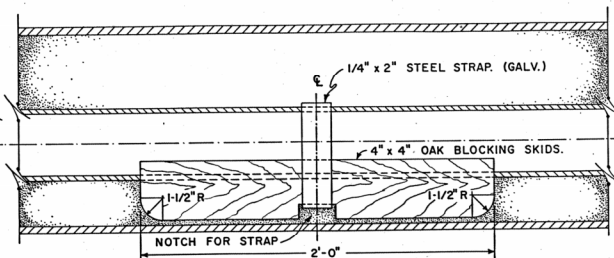


SANITARY SEWER ENCASEMENT (SEE SHEET NO 17)

PAYMENT: THE 24-INCH O.D. A.S.T.M. A-53 GRADE "B" STEEL CASING PIPE, INCLUDING THE ROUGH MILLED OAK BLOCKING; 1/4-INCH STEEL STRAPS WITH BOLTS, NUTS AND WASHER ASSEMBLIES; MASONRY BULKHEADS AND 703.02 AGGREGATE SAND FILL, SHALL BE INCLUDED IN THE CONTRACT UNIT PRICE BID PER LINEAR FOOT FOR "ITEM SPEC-24-INCH O.D.-0.594 INCH WALL CONDUIT."

GRADE "B" STEEL CASING PIPE, JACKED AND BORED IN PLACE AS PER PLAN, WHICH PRICE AND PAYMENT SHALL INCLUDE THE FURNISHING OF ALL LABOR, MATERIALS, SMALL TOOLS AND EQUIPMENT REQUIRED TO COMPLETE THIS ITEM OF WORK. THE STEEL CASING PIPE SECTIONS SHALL BE JOINED BY BUTT WELDING IN ACCORDANCE WITH 513.17.

PAYMENT WILL BE MADE FOR THE SPECIFIED SANITARY SEWER INSTALLED IN CONDUIT GRADE "B" STEEL CASING PIPE AT THE CONTRACT UNIT PRICE BID PER LINEAR FOOT FOR "ITEM 603-15" SANITARY SEWER AS PER PLAN.

NOTE: NO TRENCH EXCAVATION OR EQUIPMENT SHALL BE CLOSER THAN 10-FEET TO THE EDGE OF PAVEMENT. TRENCHES SHALL BE ADEQUATELY SUPPORTED. ALL STRAPS SHALL BE FABRICATED FROM AISI NO. C-1018, COLD FINISHED 1/4-INCH x 2-INCH FLAT BARS, WT. 1.700 LBS. PER FT. AND SHALL BE HOT-DIPPED GALVANIZED AFTER FABRICATION.

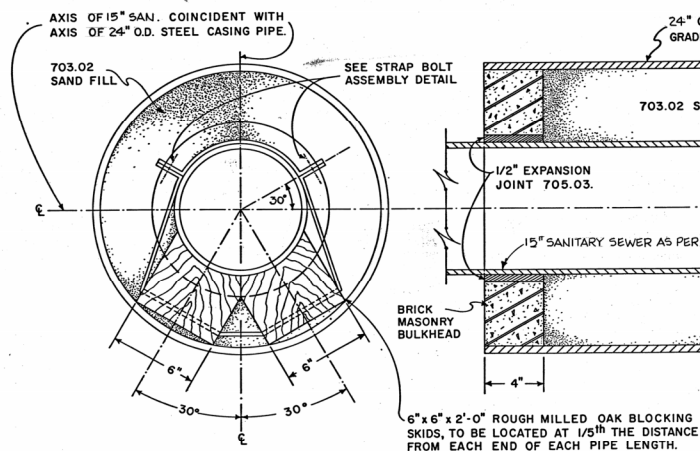

24" O.D. STEEL CASING PIPE A.S.T.M. A-53  
GRADE B, WALL THICKNESS 0.594.

703.02 SAND FILL

1/2" EXPANSION  
JOINT 705.03.

15" SANITARY SEWER AS PER PLAN

BRICK MASONRY BULKHEAD

 

6" x 6" x 2'-0" ROUGH MILLED OAK BLOCKING SKIDS, TO BE LOCATED AT 1/5th THE DISTANCE FROM EACH END OF EACH PIPE LENGTH.

1/4" x 2" STEEL STRAP (GALV.)

6" x 6" OAK BLOCKING SKIDS.

NOTCH FOR STRAP 2'-0"

LONGITUDINAL ELEVATION  
SCALE 3" = 1'-0"

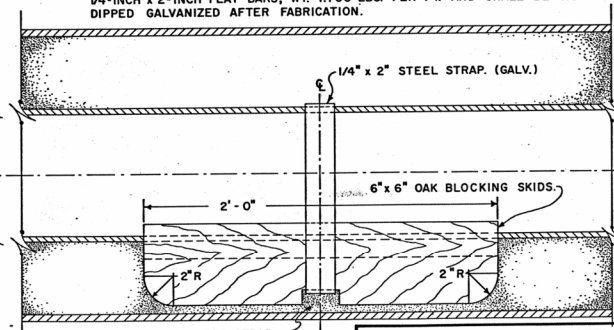

STRAP BOLT ASSEMBLY DETAIL  
FULL SCALE

|                                                                                        |      |
|----------------------------------------------------------------------------------------|------|
| BUREAU OF DESIGN SERVICES<br>DIVISION OF HIGHWAYS<br>OHIO DEPARTMENT OF TRANSPORTATION |      |
| SANITARY SEWER ENCASEMENT                                                              | DATE |
|                                                                                        |      |
|                                                                                        |      |

ORIGINAL

## NOTES

- SUBMERSIBLE PUMP SHALL BE R.E. MYERS CO., NO. 6J-52-J-511 OR APPROVED EQUAL BY CRANE CO., DEMING DIVISION; TAIT MFG. OR RAPIDAYTON. PUMP SHALL BE 3/4 H.P., 230 VOLTS, SINGLE PHASE, 60 HZ., AND HAVE A 3-WIRE MOTOR. EACH WELL PUMP INSTALLATION SHALL BE EQUIPPED WITH A LIGHTNING ARRESTOR, SUCH AS F.E. MYERS CO., NO. 12149 A10; GENERAL ELECTRIC CO., NO. 9L15BCC003 OR APPROVED EQUAL. CONNECT GROUND TO WELL CASING.




WELL PUMPS NOT HAVING A CAPACITOR (3/4 H.P. & LARGER MOTOR) SHALL BE PROVIDED WITH A MAGNETIC ACROSS-THE-LINE STARTER AND SHALL BE INCLUDED IN THE CIRCUITRY OF THE WIRING DIAGRAM.

- PITLESS ADAPTER ASSEMBLY WITH CLAMP-ON DISCHARGE FITTING BY BAKER MFG. CO., MONITOR DIVISION, NO. SPL-6-1-U-C4 (FOR 1" DROP PIPE) OR NO. SPL-6-1.2-U-C4 (FOR 1-1/4" DROP PIPE); OR APPROVED EQUAL BY DICKEN MFG. CO.; DUPLEX MFG. CO. OR WILLIAMS PRODUCT CO.
- SIX INCH I.D. (6-5/8" O.D.) WELL CASING, ASTM A 53, GRADE B, STANDARD WEIGHT, SCHEDULE 40, GALVANIZED SEAMLESS STEEL PIPE AS PER 707.11.
- ONE INCH I.D. DROP PIPE, ASTM A 53, GRADE B, STANDARD WEIGHT, SCHEDULE 40, GALVANIZED SEAMLESS STEEL PIPE AS PER 707.11.
- TWO INCH (NOMINAL SIZE) TYPE "K" HARD DRAWN COPPER WATER TUBING PRESSURE LINE CONFORMING TO ASTM B 88. RUN IN 20 FOOT LENGTHS TO HYPO-CHLORINATOR IN BUILDING, THEN EXTEND TO RESERVOIR TANK IN LIKE MANNER. (SEE DRAWINGS RRA-8 AND RRA-9).
- WATER-TIGHT CAP FOR 6" WELL CASING BY BAKER MFG. CO., MONITOR DIVISION NO. 6W; OR APPROVED EQUAL BY DICKEN MFG. CO., DUPLEX MFG. CO. OR WILLIAMS PRODUCT CO.
- CAST DEVICE BOX WITH FULL-FACE NEOPRENE GASKET AND BLANK COVER BY APPLETON ELECTRIC CO., NO. FDCC-1-100; OR APPROVED EQUAL BY KILLARK ELECTRIC MFG. CO., CROUSE-HINES CO., KONDU CORP. OR ADALET MFG. CO.
- ONE INCH DIAMETER RIGID FERROUS METAL ELECTRICAL CONDUITS PER 713.04.
- THREE-WIRE ELECTRICAL SERVICE.
- SCREENED WELL VENT TO MATCH CAP CHOSEN FROM NOTE 6 ABOVE.
- NIPPLE, ASTM A 53, GRADE B, STANDARD WEIGHT, SCHEDULE 40, GALVANIZED SEAMLESS STEEL PIPE AS PER 707.11; IF REQUIRED FOR SPECIFIC CAP USED.
- REDUCER (OF SIZE REQ'D.), IF NEEDED FOR FERROUS METAL ELECTRICAL CONDUITS AS PER 713.04.
- ELECTRODES SHALL BE B/W CONTROLLER CORP., TYPE E-1P-SHIELDED, OR APPROVED EQUAL.
- CAST BRASS MALE IRON PIPE SIZE TO COPPER ADAPTER AS PER ASTM B 16.18.

## WELL LOGS

| WELL No. 1                                   |               |                                    |  |
|----------------------------------------------|---------------|------------------------------------|--|
| South bound Rest Area No. 40                 |               |                                    |  |
| Sta. 42 + 12.5, 32.5 ft. Lt. of E. S.B. R.A. |               |                                    |  |
| Field rate 11 GPM. by bail (1) pump (1)      |               |                                    |  |
| Casing length 32 ft.                         |               |                                    |  |
| Strata at full depth gray sand & gravel      |               |                                    |  |
| Recommended sieve size                       |               |                                    |  |
| Item                                         | Elevation     | Depth in feet below original grade |  |
| Top of casing                                | +1 1114.8     |                                    |  |
| Original grade                               | 1113.8        |                                    |  |
| Finish grade                                 | 1113.8        |                                    |  |
| Static water level                           | 1092.8        | 21                                 |  |
| Drawdown                                     |               | 15                                 |  |
| Bottom of casing                             | 1075.2        |                                    |  |
| stain. steel screen                          | Top 1076.8    |                                    |  |
|                                              | Bottom 1066.8 |                                    |  |
| Total drilled depth                          | 1066.8        | 47'                                |  |

\* If actual static water level is not as indicated, the start electrodes are to be set 5'-0" below measured level.

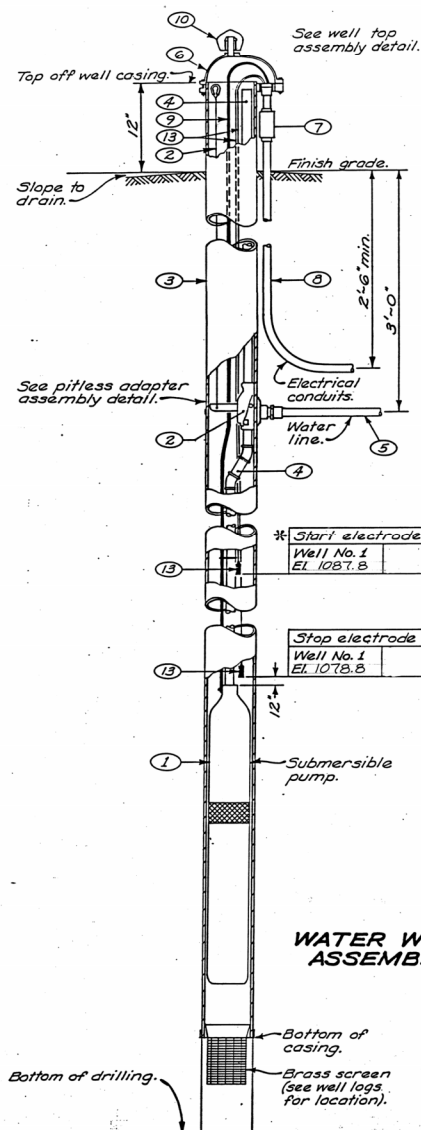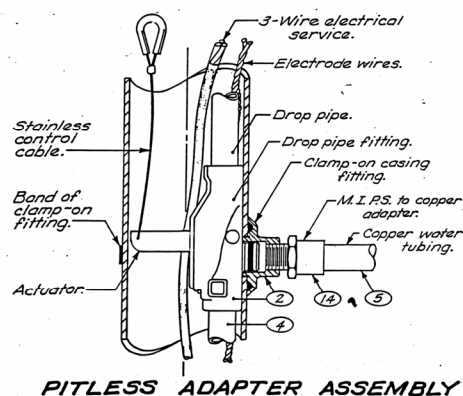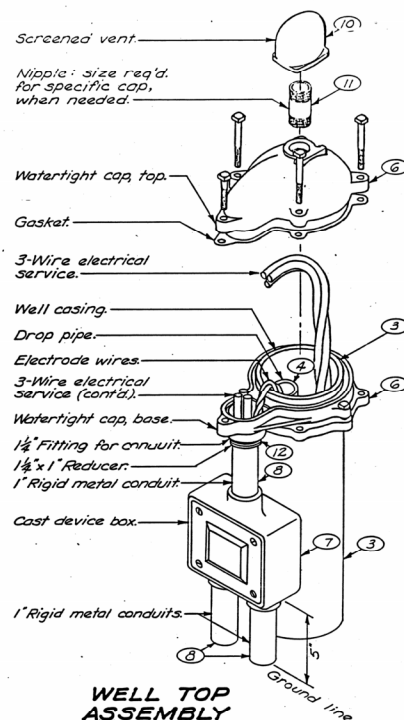

|                                                                                        |  |
|----------------------------------------------------------------------------------------|--|
| BUREAU OF DESIGN SERVICES<br>DIVISION OF HIGHWAYS<br>OHIO DEPARTMENT OF TRANSPORTATION |  |
| DATE<br>9/2/82                                                                         |  |
| WATER WELL ASSEMBLY                                                                    |  |
| RRA-7                                                                                  |  |
| APPROVED <i>[Signature]</i> Engr. of Design Services                                   |  |

## NOTES


1. SOUTH BOUND REST AREA - INSTALL A DOLE VALVE CO. FLOW CONTROL VALVE NO. 6X WITH 11 G.P.M. FLOW, 1" F.N.P.T. INLET AND OUTLET, FOR GENERAL USE, NICKEL PLATED.

2. ONLY 5 1/4% OR 15% UNDILUTED LIQUID, SODIUM HYPOCHLORITE SOLUTION SHALL BE USED IN THIS SYSTEM. THE SYSTEM MUST BE MAINTAINED AT A MINIMUM OF 1/3 FULL OR COMPLETELY FILLED (17 TO 50 GALLONS) TO FUNCTION PROPERLY.

3. THE PLUMBING CONTRACTOR SHALL FURNISH AND INSTALL 50 GALLONS OF UNDILUTED SODIUM HYPOCHLORITE SOLUTION AND REGULATE METER AND TEST FOR REQUIRED CHLORINE RESIDUE PER ENGINEERS APPROVAL.

4. THE SODIUM HYPOCHLORITE CHLORINATOR SYSTEM IS BASED ON ALL EQUIPMENT AND APPURTENANCES AS SPECIFIED AND/OR SHOWN ON PLANS, AS MANUFACTURED BY LIQUID METRONIC INCORPORATED. LIKE EQUIPMENT AND APPURTENANCES AS MANUFACTURED BY HVC COMPANY OF CINCINNATI (PROMINENT PUMP UNIT) OR APPROVED EQUAL MAY BE SUBMITTED, SUBJECT TO ENGINEERS APPROVAL.

5. M.I.P.S. X C. ADAPTER SHALL BE ADJACENT TO ALL VALVES, UNIONS AND SPECIAL DEVICES.

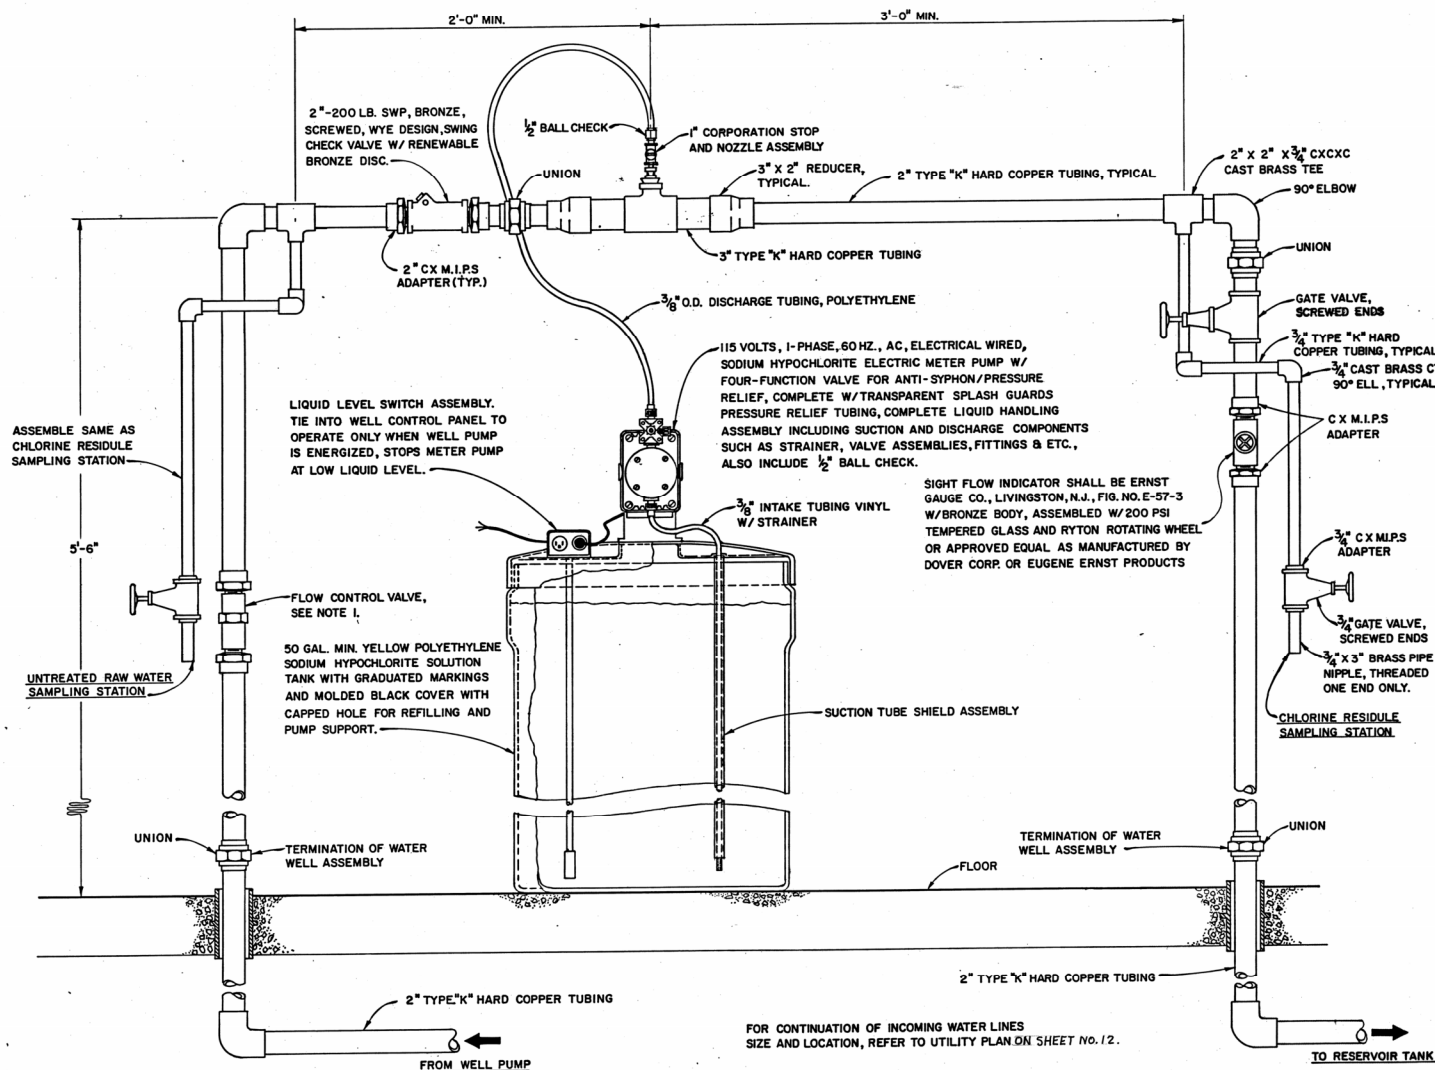

BUREAU OF DESIGN SERVICES  
DIVISION OF HIGHWAYS  
OHIO DEPARTMENT OF TRANSPORTATION

ROADWAY DEVELOPMENT

DATE


WATER SYSTEM  
HYPOCHLORINATOR

8-14-84


RRA-8

APPROVED *[Signature]* Engr. of Design Services



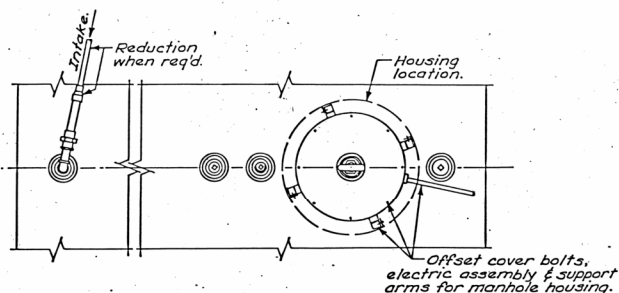

PLUMBING AND ELECTRIC - PLAN

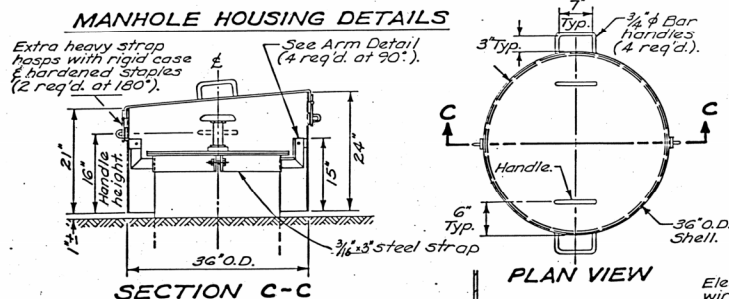


WELDS: Arms, bar clips, handles, hoops and staples shall be fillet welded all around.


Shell and lid shall be coated inside and outside with red oxide primer (708.19) and green finish paint (708.09).

Arms shall be covered by the same outside coating required on the tank, manhole and manhole cover.


Two padlocks equal to Master No. 425A or Wilson Bohannon 660 and meeting the corrosion and keying requirements of 631.08 shall be furnished with each housing.

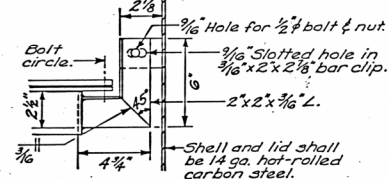


ARM DETAIL

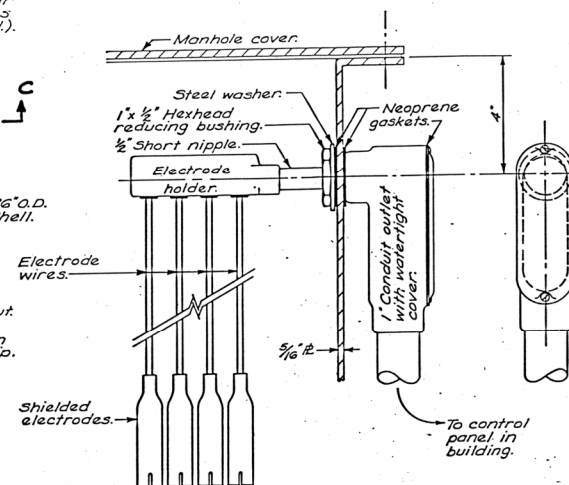

ELECTRICAL ASSEMBLY

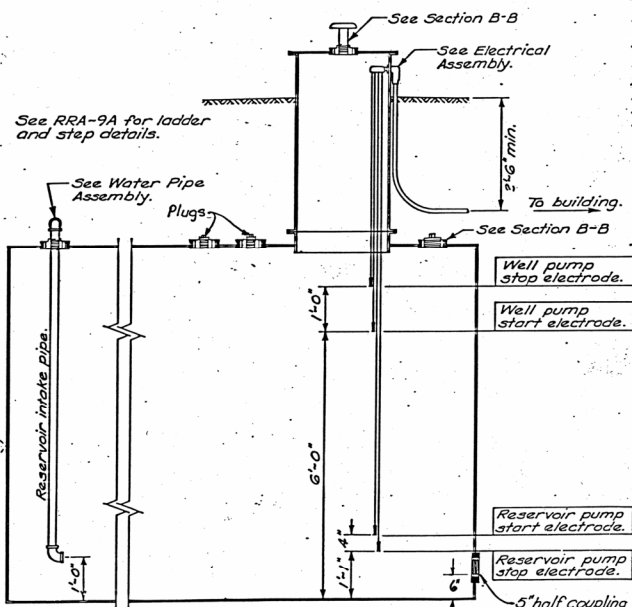

- PLUMBING AND ELECTRIC - SECTION

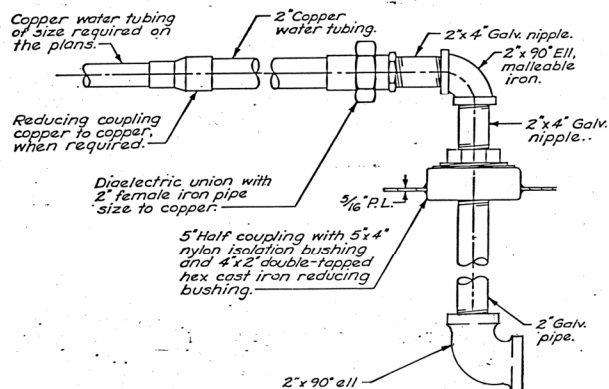

WATER PIPE ASSEMBLY

BUREAU OF DESIGN SERVICES  
DIVISION OF HIGHWAYS  
OHIO DEPARTMENT OF TRANSPORTATION

WATER RESERVOIR TANK  
(MODIFIED)

RRA-9A





APPROVED *G. L. Allen* Engr. of Design Services

DATE  
9/2/62



## NOTES

- SUBMERSIBLE PUMP (2 REQ'D. PER WEST AREA) SHALL BE F.E. MYERS CO. MODEL NO. SJF-3021-J-3050 OR APPROVED EQUAL. PUMP SHALL BE 3/4" H.P., 230V., SINGLE PHASE, 60 HZ. AND HAVE 3-WIRE MOTOR. THE MOTOR SHALL BE PROVIDED WITH A MAGNETIC ACROSS-THE-LINE STARTER AND SHALL BE INCLUDED IN THE CIRCUITRY OF THE WIRING DIAGRAM.
- EACH PUMP INSTALLATION SHALL BE EQUIPPED WITH A LIGHTING ARRESTOR, SUCH AS F.E. MYERS CO., NO. 12149A10; GENERAL ELECTRIC CO., NO. 9L15BCC003 OR APPROVED EQUAL. GROUND SHALL BE CONNECTED TO CASING.
- PITLESS ADAPTER ASSEMBLY WITH CLAMP-ON DISCHARGE FITTING BY BAKER MFG. CO., MONITOR DIVISION, NO. SPL-6-U-CA (FOR 1" DROP PIPE) OR APPROVED EQUAL BY DICKEN MFG. CO.; DUPLEX MFG. CO. OR WILLIAMS PRODUCT CO.
- SIX INCH I.D. (6-5/8" O.D.) WELL CASING, ASTM A 53, GRADE B, STANDARD WEIGHT, SCHEDULE 40, GALVANIZED SEAMLESS STEEL PIPE AS PER 707.11.
- 1" I.D. DROP PIPE, ASTM A 53, GRADE B, STANDARD WEIGHT, SCHEDULE 40, GALVANIZED SEAMLESS STEEL PIPE AS PER 707.11.
- 2 INCH (NOMINAL SIZE) TYPE "K" HARD DRAWN COPPER WATER TUBING PRESSURE LINE CONFORMING TO ASTM B 88. RUN IN 20 FOOT LENGTHS TO HYDRO-PNEUMATIC PRESSURE TANK IN BUILDING.
- WATER-TIGHT CAP FOR 6" WELL CASING BY BAKER MFG. CO., MONITOR DIVISION NO. 6N; OR APPROVED EQUAL BY DICKEN MFG. CO.; DUPLEX MFG. CO. OR WILLIAMS PRODUCT CO.
- CAST DEVICE BOX WITH FULL-FACE NEOPRENE GASKET AND BLANK COVER BY APPLETON ELECTRIC CO., NO. FDCC-1-100; OR APPROVED EQUAL BY KILLARK ELECTRIC MFG. CO., CROUSE-HINES CO., KODU CORP. OR ADALET MFG. CO.
- TWO INCH DIAMETER RIGID FERROUS METAL ELECTRICAL CONDUIT PER 713.04.
- THREE-WIRE ELECTRICAL SERVICE.
- SCREENED WELL VENT TO MATCH CHOSEN FROM NOTE 6 ABOVE.
- NIPPLE, ASTM A 53, GRADE B, STANDARD WEIGHT, SCHEDULE 40, GALVANIZED SEAMLESS STEEL PIPE AS PER 707.11; IF REQUIRED FOR SPECIFIC CAP USED.
- REDUCER (OF SIZE REQ'D.), IF NEEDED FOR FERROUS METAL ELECTRICAL CONDUIT AS PER 713.04.
- CAST BRASS MALE IRON PIPE SIZE TO COPPER ADAPTER AS PER ASTM B 16.13.

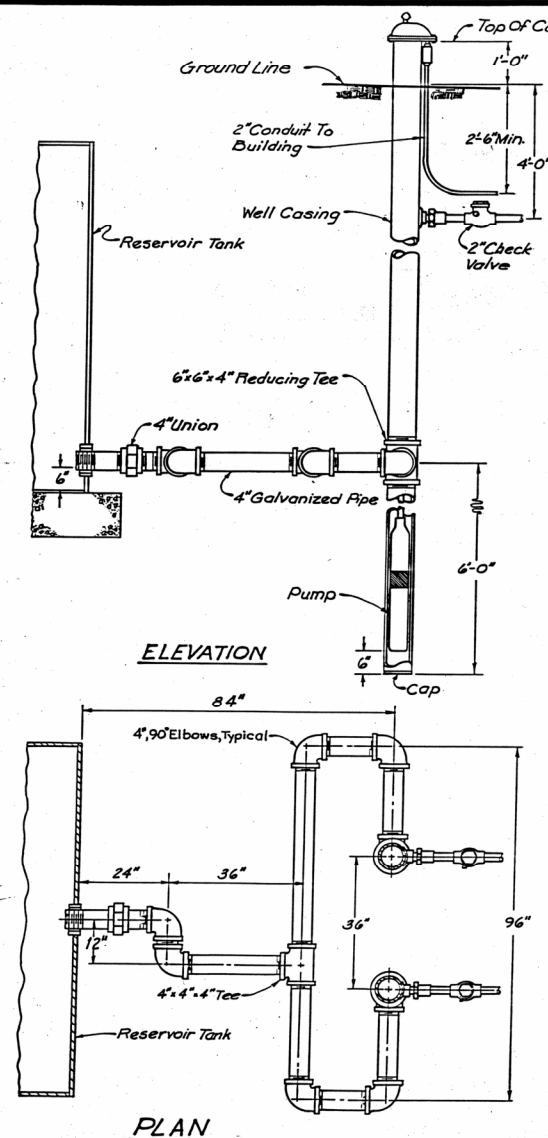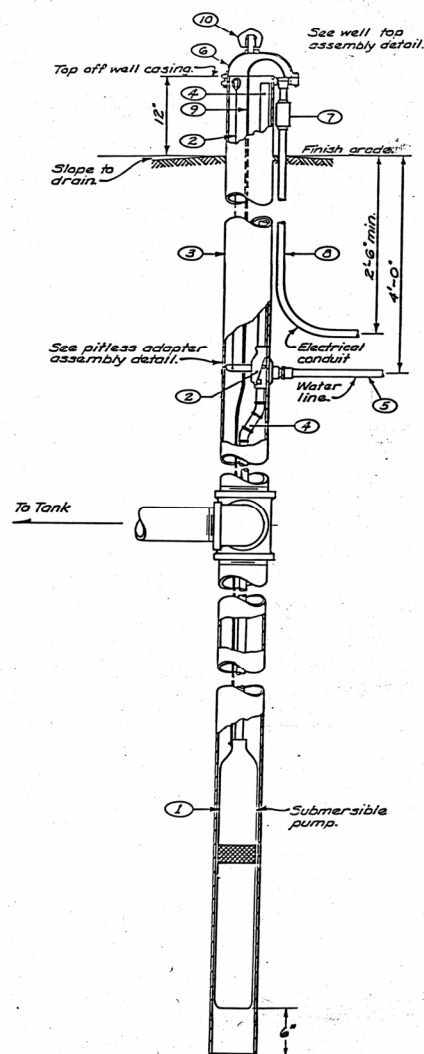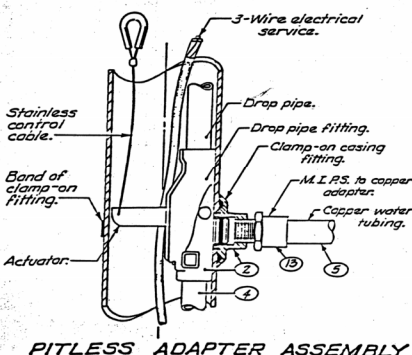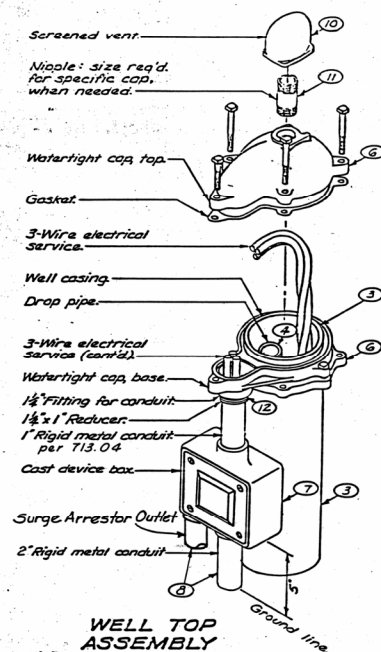

|                                                                                        |                          |
|----------------------------------------------------------------------------------------|--------------------------|
| BUREAU OF DESIGN SERVICES<br>DIVISION OF HIGHWAYS<br>OHIO DEPARTMENT OF TRANSPORTATION |                          |
| ROADSIDE DEVELOPMENT                                                                   | DATE<br>9/8/84           |
| RESERVOIR PUMP DETAILS                                                                 |                          |
| RRA-10                                                                                 |                          |
| APPROVED                                                                               | Engr. of Design Services |




CALC. BY: 7/10/82  
DATE: 7/10/82  
CHKD. BY:  
DATE:

MEDINA COUNTY  
MED-71-22.14

OHIO  
FHWA REGION 5

MEDINA COUNTY  
MED-71-22.14 (S.B.)  
IR-71-4(57)224 PART I

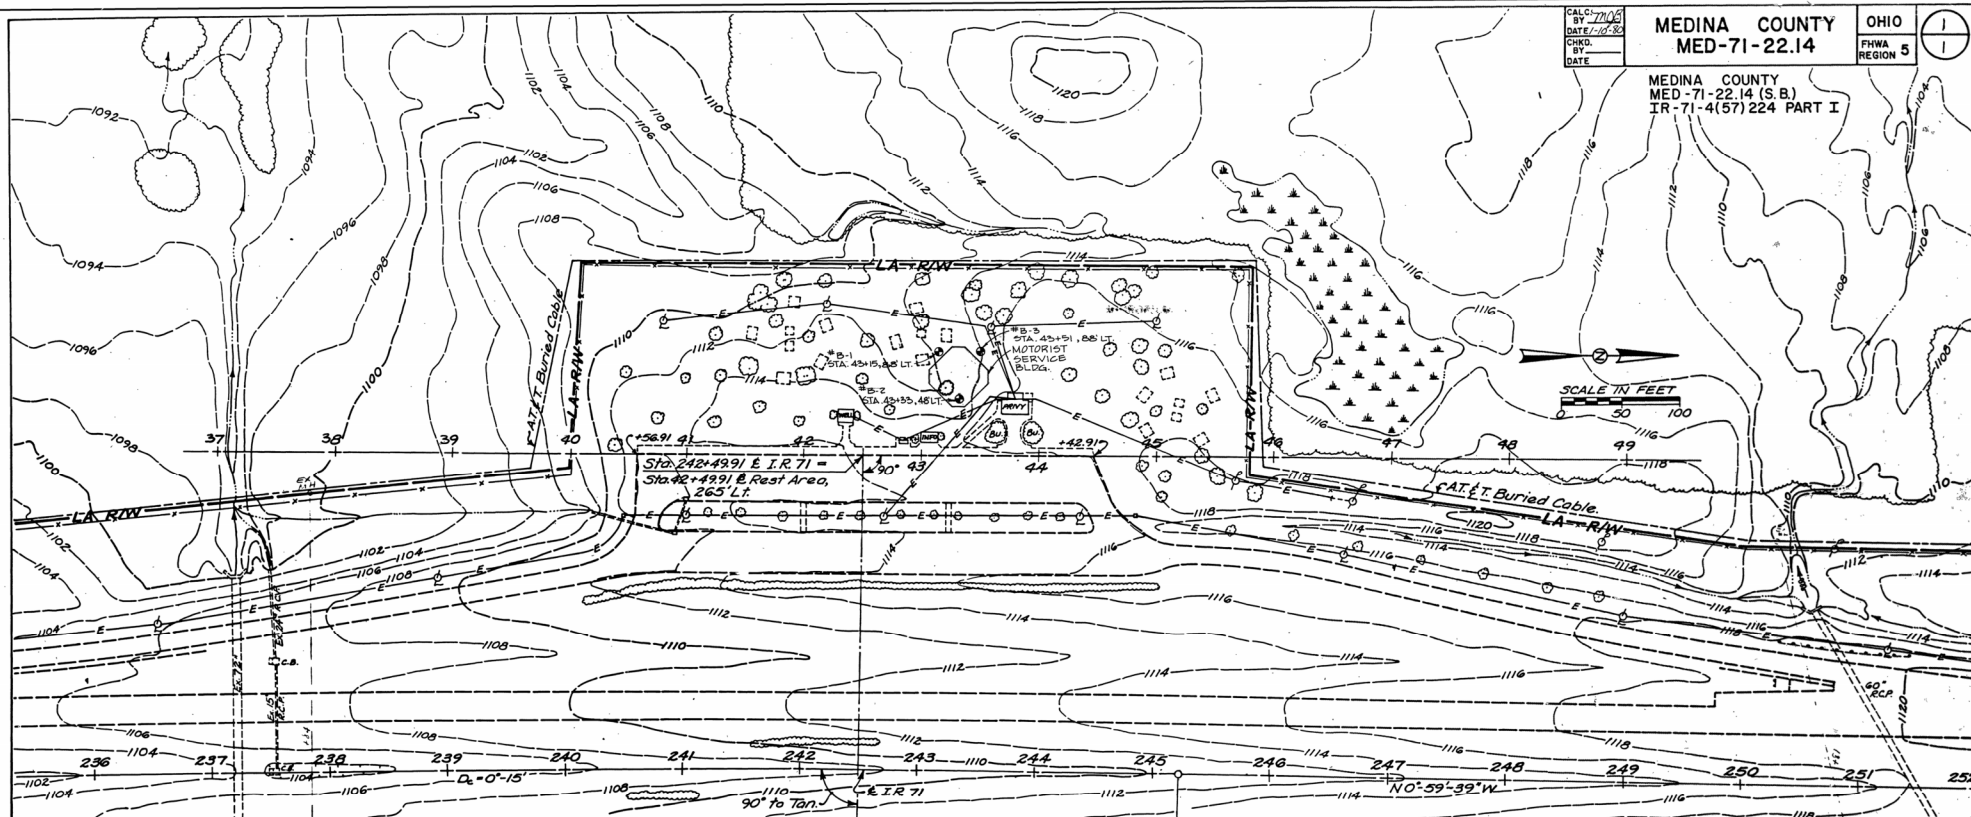

LOG OF BORING  
Date Started: 11-15-82 Sample Type: SS Dia: 1 3/8" Water Elev: 1109.4'  
Date Completed: 11-15-82 Casing Length: 0' 0" 0"

Boring No. B-1 Station & Offset: 43+15 88' LT. Surface Elev: 1111.9'

| Elev   | Depth | Stk     | Pen | Description                          | ALLOW. BEAR. CAP. TSF | Field No. | Lab. No. | Physical Characteristics | SHTL. Class |
|--------|-------|---------|-----|--------------------------------------|-----------------------|-----------|----------|--------------------------|-------------|
| 1111.9 | 0     |         |     |                                      |                       |           |          |                          |             |
| 1109.4 | 2     |         |     |                                      |                       |           |          |                          |             |
| 1806.9 | 4     | 2/5/8   |     | BROWN SANDY CLAYEY SILT              | 2.5                   | 1         | 30899    | 7 6 12 40 35 32 8 20     | A-4a        |
| 1104.4 | 6     | 4/7/13  |     | BROWN SANDY CLAYEY SILT W/ ST. FRAGS | 3.0                   | 2         | 30900    | 14 9 12 36 29 27 7 15    | A-4a        |
| 1101.0 | 10    | 3/6/9   |     | BROWN SANDY CLAYEY SILT              | 2.5                   | 3         | 30901    | 4 6 9 44 37 28 7 17      | A-4a        |
| 1099.4 | 12    | 4/8/9   |     | GRAY SANDY CLAYEY SILT W/ ST. FRAGS  | 2.5                   | 4         | 30902    | 11 8 13 39 29 22 5 13    | A-4a        |
| 1096.9 | 14    | 5/6/10  |     | GRAY SANDY CLAYEY SILT               | 2.5                   | 5         | 30903    | 8 5 12 43 32 26 7 14     | A-4a        |
| 1094.4 | 16    | 4/2/12  |     | GRAY SANDY CLAYEY SILT               | 3.0                   | 6         | 30904    | 8 11 17 34 30 27 7 15    | A-4a        |
| 1091.9 | 20    | 5/0/11  |     | GRAY CLAYEY SILT WITH CORBELS        | 3.0                   | 7         | 30905    | 11 1 3 30 55 25 6 18     | A-4a        |
| 1090.4 | 24    | 8/18/13 |     | GRAY CLAYEY SILT AND GRAVEL          | 4.0                   | 8         | 30906    | 51 6 5 15 23 26 7 19     | A-4a        |
|        | 26    |         |     | BOTTOM OF BORING                     |                       |           |          |                          |             |

LOG OF BORING  
Date Started: 11-15-82 Sample Type: SS Dia: 1 3/8" Water Elev: 1105.9'  
Date Completed: 11-15-82 Casing Length: 0' 0" 0"

Boring No. B-2 Station & Offset: 43+51 88' LT. Surface Elev: 1113.4'

| Elev   | Depth | Stk      | Pen | Description                          | ALLOW. BEAR. CAP. TSF | Field No. | Lab. No. | Physical Characteristics | SHTL. Class |
|--------|-------|----------|-----|--------------------------------------|-----------------------|-----------|----------|--------------------------|-------------|
| 1113.4 | 0     |          |     |                                      |                       |           |          |                          |             |
| 1110.9 | 2     |          |     |                                      |                       |           |          |                          |             |
| 1108.4 | 4     | 7/9/11   |     | BROWN AND GRAY SANDY CLAYEY SILT     | 3.5                   | 1         | 30907    | 9 5 12 40 34 33 10 18    | A-4a        |
| 1105.9 | 6     | 9/10/12  |     | BROWN CLAYEY SANDY SILT W/ ST. FRAGS | 3.5                   | 2         | 30908    | 14 17 26 24 19 23 6 15   | A-4a        |
| 1103.4 | 10    | 8/13/18  |     | BROWN CLAYEY SANDY SILT W/ ST. FRAGS | 4.0                   | 3         | 30909    | 10 11 17 37 25 25 7 15   | A-4a        |
| 1100.9 | 12    | 8/15/23  |     | BROWN SILTY SAND W/ ST. FRAGS        | 4.0                   | 4         | 30910    | 13 29 23 23 12 25 7 15   | A-2-4       |
| 1098.4 | 14    | 10/18/23 |     | GRAY SANDY CLAYEY SILT W/ ST. FRAGS  | 4.5                   | 5         | 30911    | 12 7 13 39 29 28 8 13    | A-4a        |
| 1095.9 | 16    | 9/16/18  |     | GRAY CLAYEY SILT                     | 4.5                   | 6         | 30912    | 0 0 1 56 43 28 8 22      | A-4b        |
| 1093.4 | 18    | 13/18/20 |     | GRAY SILT AND CLAY                   | 4.5                   | 7         | 30913    | 0 1 1 45 53 30 11 25     | A-6a        |
| 1091.9 | 20    | 2/23/18  |     | GRAY SILTY SANDY GRAVEL              | 5.0                   | 8         | 30914    | 45 14 10 16 15 25 8 12   | A-2-4       |
|        | 24    |          |     | BOTTOM OF BORING                     |                       |           |          |                          |             |

LOG OF BORING  
Date Started: 11-9-82 Sample Type: SS Dia: 1 3/8" Water Elev: 1108.1'  
Date Completed: 11-10-82 Casing Length: 0' 0" 0"

Boring No. B-3 Station & Offset: 43+33 68' LT. Surface Elev: 1112.3'

| Elev   | Depth | Stk      | Pen | Description                                            | ALLOW. BEAR. CAP. TSF | Field No. | Lab. No. | Physical Characteristics | SHTL. Class |
|--------|-------|----------|-----|--------------------------------------------------------|-----------------------|-----------|----------|--------------------------|-------------|
| 1112.3 | 0     |          |     |                                                        |                       |           |          |                          |             |
| 1109.8 | 2     |          |     |                                                        |                       |           |          |                          |             |
| 1107.3 | 4     | 10/10/16 |     | BROWN CLAY AND SILT WITH 0.3" SOD                      | 4.0                   | 1         | 30773    | 11 7 9 41 32 26 2 16     | A-4a        |
| 1104.8 | 6     | P.S.     |     | BROWN AND GRAY SANDY CLAYEY SILT                       | 3.14 TSF              | 2         | 30808    | 7 5 10 50 28 28 7 15     | A-4b        |
| 1102.3 | 10    | 8/12/19  |     | BROWN SANDY CLAYEY SILT                                | 4.0                   | 3         | 30775    | 7 6 11 44 32 24 5 13     | A-4a        |
| 1099.8 | 12    | 6/8/12   |     | BROWN AND GRAY SANDY CLAYEY SILT                       | 3.0                   | 4         | 30776    | 3 10 27 32 28 20 4 23    | A-4a        |
| 1097.3 | 14    | P.S.     |     | BROWN SANDY CLAYEY SILT                                |                       | 5         | 30809    | 7 5 9 37 42 28 9 19      | A-4a        |
| 1094.8 | 16    | 6/23/24  |     | GRAY SANDY CLAYEY SILT                                 | 5.0                   | 6         | 30810    | 0 0 1 35 65 23 11 21     | A-6a        |
| 1092.3 | 20    | 12/16/12 |     | BROWN WITH GRAY SANDY CLAYEY SILT WITH STONE FRAGS     | 4.0                   | 7         | 30778    | 46 23 11 14 6 21 5 18    | A-1-b       |
| 1089.8 | 24    | 6/7/13   |     | GRAY SANDY GRAVEL                                      | 4.0                   | 8         | 30779    | 75 7 10 39 29 26 6 14    | A-4a        |
| 1087.3 | 26    | 6/9/11   |     | BROWN WITH GRAY SANDY CLAYEY SILT WITH STONE FRAGMENTS | 3.0                   | 9         | 30781    | 12 9 27 36 14 NP NP 17   | A-4a        |
|        | 28    |          |     | BOTTOM OF BORING                                       |                       |           |          |                          |             |

\* NO STRENGTH TESTS PERFORMED

SOIL BORING INFORMATION - SOUTHBOUND

STATE OF OHIO  
DEPARTMENT OF TRANSPORTATION

# MED-71-22.14

SAFETY REST AREA

MEDINA COUNTY  
BRUNSWICK TOWNSHIP

|                                                |                          |
|------------------------------------------------|--------------------------|
| MEDINA COUNTY<br>MED-71-22.14 SB.<br>REST AREA | OHIO<br>FHWA<br>REGION 5 |
| IR-71-4(57)224                                 | FEDERAL<br>PROJECT       |

IR-71-4(57)224 PART I  
FOR PART II, SEE MED-71-22.50

## LIMITED ACCESS

This improvement is especially designed for through traffic and has been declared a limited access highway or freeway by action of the Director of Transportation in accordance with the provisions of Section 5511.02 of the Revised Code of Ohio.

## 1983 SPECIFICATIONS

The standard specifications of the State of Ohio, Department of Transportation, including changes and supplemental specifications listed in the proposal shall govern this improvement.


I hereby approve these plans and declare that the making of this improvement will not require the closing of the highway, except for the affected rest area, and that provisions for maintenance and safety of traffic will be set forth in these plans and estimate.

## CONVENTIONAL SIGNS

|                                        |                                   |         |
|----------------------------------------|-----------------------------------|---------|
| County Line                            | Limited Access (only)             | LA      |
| Township Line                          | Right of Way (only)               | RW      |
| Section Line                           | Limited Access & Right of Way     | LA & RW |
| Corporation Line                       | Existing Right of Way             |         |
| Fence Line (existing)                  | Property Line (in existing fence) |         |
| Center Line                            | Railroad                          |         |
| Trees, Stumps, (to be removed)         | Guardrail (existing)              |         |
| Utility Poles: Telephone, Power, Light |                                   |         |

## INDEX OF SHEETS

|                                    |            |
|------------------------------------|------------|
| TITLE SHEET                        | 1          |
| GENERAL NOTES                      | 2-3        |
| MAINTENANCE OF TRAFFIC             | 4, 4A      |
| GENERAL SUMMARY                    | 5-7        |
| SITE PLAN                          | 8          |
| REMOVAL AND TREE PROTECTION PLAN   | 9          |
| LAYOUT PLAN                        | 10         |
| GRADING PLAN                       | 11         |
| UTILITIES PLAN                     | 12-14, 14A |
| SANITARY SEWER PLAN/PROFILE        | 15-19      |
| MOTORIST SERVICES BUILDING DETAILS | 20-40, 36A |
| OTHER DETAIL DRAWINGS              | 41-47      |

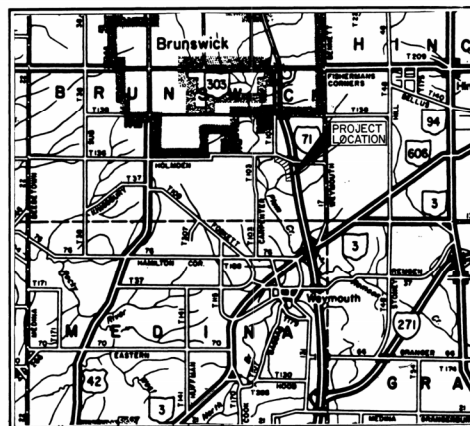

LOCATION MAP

SCALE IN MILES  
0 1 2 3 4

|                        |  |
|------------------------|--|
| Portion to be improved |  |
| State & Federal Routes |  |
| Other Roads            |  |

## SCALES

|                             |                |
|-----------------------------|----------------|
| Plan Sewage Treatment Plant | 0 5 10         |
| Profile: S.T.P. Horizontal  | 0 5 10         |
| Site Plans:                 | 0 20 40 50 100 |

| SUPPLEMENTAL SPECIFICATIONS                                                                      |          |     |         |
|--------------------------------------------------------------------------------------------------|----------|-----|---------|
| SPECIAL: STANDARD SPECIFICATIONS FOR MOTORIST SERVICES BUILDING AND STORAGE UNIT PART I 11-15-84 |          |     |         |
| 839                                                                                              | 11-25-70 | 803 | 5-27-83 |
| 814                                                                                              | 1-1-69   | 824 | 10-8-82 |

|                                                        |                            |
|--------------------------------------------------------|----------------------------|
| NET LENGTH OF PROJECT = 0.00 LIN. FT. OR 0.000 MILE    | I.R.-71 SLEEPY HOLLOW      |
| BEGIN WORK STA. 240+45                                 | STA. 0+00                  |
| END WORK STA. 261+77                                   | STA. 23+88                 |
| LENGTH OF WORK 2132 LIN. FT. OR 0.404 MI.              | 2388 LIN. FT. OR 0.452 MI. |
| TOTAL NET LENGTH OF WORK = 4520 LIN. FT. OR 0.856 MILE |                            |



Plan Prepared By:  
JOHN DAVID JONES AND ASSOCIATES, INC.  
CONSULTING ENGINEERS ARCHITECTS PLANNERS  
2162 FRONT STREET CUYAHOGA FALLS, OHIO

| SUPPLEMENTAL PRINTS OF STANDARD CONSTRUCTION DRAWINGS |          |       |          |
|-------------------------------------------------------|----------|-------|----------|
| BP-6                                                  | 6-1-65   | MH-1  | 6-12-75  |
| BP-7                                                  | 12-6-76  | MH-3  | 6-12-75  |
| BP-12                                                 | 7-7-81   | LA-1  | 6-1-79   |
| CB-2-2-A&B                                            | 5-1-79   | LA-10 | 6-1-79   |
| HW-4B                                                 | 4-1-80   | LA-13 | 2-2-81   |
| F-1                                                   | 11-10-83 | LA-14 | 12-22-82 |
| F-2                                                   | 5-1-76   | LA-15 | 8-1-84   |
| MC-4                                                  | 7-26-76  | LA-16 | 12-22-82 |
| MC-9A                                                 | 5-1-81   | LA-2  | 6-1-79   |
| MC-11                                                 | 8-1-78   | MH-5  | 6-12-75  |
| CB-3A                                                 | 5-1-79   | LA-11 | 6-1-79   |
| # FOR REFERENCE ONLY                                  |          |       |          |

Approved: *Wayne H. Kaulle*  
Date: 12/27/84 District Deputy Director of Transportation

Approved: *Wayne H. Kaulle*  
Date: 3/7/85 Engineer of Design Services

Approved: *Wayne H. Kaulle*  
Date: 2-25-85 Chief Engineer, Planning and Design

Approved: *Wayne H. Kaulle*  
Date: 2-25-85 Director, Department of Transportation

DEPARTMENT OF TRANSPORTATION  
FEDERAL HIGHWAY ADMINISTRATION

APPROVED:

DIVISION ADMINISTRATOR DATE

Project: MED-71-22.14 SB.

Date of Letting: 19, Contract No.

LD0300 Rev. 11-1-78

Rev. 28-85

# GENERAL

## ITEM 603 - JACKING PIPE

AS PART OF THIS CONTRACT, IT WILL BE NECESSARY TO INSTALL A 24" CONDUIT UNDER AN EXISTING 10" X 4.5 CONCRETE BOX CULVERT FROM STA. 4+17 TO STA. 4+17 SLEEPY HOLLOW ROAD BY THE METHOD OF BORING AND JACKING.

TRENCHES SHALL BE ADEQUATELY SUPPORTED AND THE SPECIFICATION REQUIREMENT FOR CLASS C BEDDING SHALL BE DISREGARDED. THE MATERIAL SHALL CONFORM TO ASTM A53, GRADE B. THE WORK SHALL BE PAID FOR UNDER:

ITEM 603 - 24" SCHEDULE 40 GALVANIZED STEEL, P.E. PIPE, ASTM A53, CLASS B, JACKED AS PER PLAN.

## ITEM 603 - (4" 6" 8") DUCTILE IRON PIPE, AS PER PLAN

THE REQUIREMENTS OF 603 SHALL GOVERN THE FURNISHING AND INSTALLATION OF THIS PIPE EXCEPT AS HEREINAFTER MODIFIED. THE CONSTRUCTION REQUIREMENTS OF TYPE C CONDUIT SHALL GOVERN.

IN LIEU OF THE REQUIREMENTS OF 603.02, THE MATERIAL FURNISHED FOR THIS ITEM SHALL BE MECHANICAL JOINT DUCTILE CAST IRON PIPE, CONFORMING TO ANSI/AWWA-C151/A21.51/CLASS 53.

## SANITARY WYES AND RISERS

INSTALLATION OF SANITARY WYES AND RISERS SHALL BE DONE IN ACCORDANCE WITH THE STANDARDS AND SPECIFICATIONS OF THE MEDINA COUNTY SANITARY ENGINEER.

AN APPROXIMATE LOCATION OF THE WYES AND RISERS IS SHOWN ON SHEET NO. 12. THE EXACT LOCATION WILL BE DETERMINED BY THE MEDINA COUNTY SANITARY ENGINEER.

PAYMENT WILL BE INCLUDED IN THE CONTRACT UNIT PRICE BID PER LINEAR FOOT OF 8" SANITARY SEWER AS PER PLAN.

## ITEM 603 - 8" OR 15" SANITARY SEWER AS PER PLAN

1. ALL SANITARY SEWERS AND APPURTENANCES SHALL BE CONSTRUCTED IN ACCORDANCE WITH THE MEDINA COUNTY SANITARY ENGINEERING (MCSE) DEPARTMENT'S RULES AND REGULATIONS.

2. MEDINA COUNTY SANITARY ENGINEERING DEPARTMENT REGULATIONS PROHIBIT ROOF DRAINS, FOUNDATION DRAINS, OR ANY OTHER CLEAR OR SURFACE WATER CONNECTIONS TO SANITARY SEWERS. THIS REGULATION IS STRICTLY ENFORCED BY MCSE.

3. SANITARY SEWER PIPES MAY BE COMPOSED OF ONE OF THE FOLLOWING MATERIALS:

- ACRYLONITRILE BUTADIENE STYRENE (ABS) COMPOSITE, ASTM D2680, WITH JOINTS AS PER ASTM D2680 CHEMICALLY WELDED USING A STANDARD ABS COUPLING AND LATERALS AS PER ASTM D2751 WITH MINIMUM PIPE STIFFNESS OR SDR EQUAL TO 200 PSI.
- POLYVINYL CHLORIDE (PVC), ASTM D3034, WITH JOINTS AS PER ASTM 3212 COMPRESSION TYPE AND LATERALS AS PER ASTM D3034 WITH MINIMUM PIPE STIFFNESS OR SDR EQUAL TO SDR 35, SDR 33.5 FOR LATERALS.
- VITRIFIED CLAY (VCP), ASTM C700, WITH JOINTS AS PER ASTM C425 AND LATERALS AS PER ASTM C700.

4. ALL ROAD SURFACES, EASEMENTS OR RIGHT-OF-WAYS DISTURBED BY CONSTRUCTION OR ANY PART OF THIS SANITARY IMPROVEMENT ARE TO BE RESTORED COMPLETELY TO THE BEFORE CONSTRUCTION CONDITION OR BETTER. FOR EXISTING SLEEPY HOLLOW ROAD TYPICAL SECTION SEE SHEET NO. 12.

14A. A LUMP SUM FEE OF \$9870 PER LOT SHALL BE PAID TO THE MEDINA COUNTY SANITARY DEPARTMENT IN ACCORDANCE WITH SEC. 107.02 OF THE SPECIFICATIONS.

5. THE CONTRACTOR SHALL KEEP OPEN AND CLEAN ALL DITCHES, RESTORE ALL DRAINAGE STRUCTURES WITHIN THE LIMITS OF CONSTRUCTION, REPLACE, IN KIND, ALL DRIVEWAY APPROACHES, AND FINE GRADE AND SEED ALL AREAS DISTURBED BY THIS CONSTRUCTION OTHER THAN PAVEMENT AND BERMS.

6. FOR VITRIFIED CLAY PIPE TRENCH CONDITIONS, SEE DETAIL SHEET NO. 41.

7. ABS AND PVC PIPE TRENCH CONDITIONS:

- USE CLASS "B" BEDDING PER ODOT SECTION 603.04. THE MATERIAL FOR THIS BEDDING SHALL MEET ODOT SPECIFICATIONS FOR NUMBERS 6, 47 OR 68 COARSE AGGREGATE AND SHALL BE GRAVEL, LIMESTONE OR SLAG.
- TRENCH WIDTHS SHALL BE PER MCSE STANDARD FOR VITRIFIED CLAY PIPE. (SEE DETAIL SHEET NO. 41.)
- TRENCHES IN PAVED AREAS OR PROPOSED PAVED AREAS SHALL BE BACKFILLED WITH EITHER LIMESTONE OR SLAG SCREENINGS TO PAVEMENT BASE, UNLESS OTHERWISE SPECIFIED BY THE AUTHORITY HAVING PAVEMENT MAINTENANCE RESPONSIBILITY.
- FOR ABS, MODIFY ODOT SECTION 603.04 TO CARRY THE BEDDING MATERIAL TO A MINIMUM OF SIX INCHES (6") ABOVE THE PIPE.
- FOR PVC, IN ADDITION TO ODOT CLASS "B" BEDDING, THE TRENCH SHALL BE BACKFILLED WITH COMPACTED LIMESTONE SCREENINGS TO A MINIMUM OF SIX INCHES (6") ABOVE THE TOP OF THE PIPE.

8. TESTING

A. PHOTOGRAPHIC OR TV INSPECTION OF ALL SANITARY SEWERS AND PASSAGE OF A STANDARD INFILTRATION TEST SHALL BE REQUIRED BEFORE THE ACCEPTANCE OF THE SANITARY SEWER BY THE MEDINA COUNTY SANITARY ENGINEERING DEPARTMENT OR ODOT.

B. DEFLECTION TESTS WILL BE RUN ON ALL PVC PIPE, NOT LESS THAN 30 DAYS AFTER FINAL FULL BACKFILL HAS BEEN PLACED. NO PIPE SHALL EXCEED A DEFLECTION OF 5%. THESE TESTS SHALL CONSIST OF PULLING A "GO-NO-GO" MANDREL THROUGH THE LINE. THE CONTRACTOR HAS THE OPTION OF:

- THE COUNTY PERFORMING SAID WORK (FEE REQUIRED).
- THE CONTRACTOR PERFORMING THE WORK UNDER COUNTY SUPERVISION.

C. MAXIMUM ALLOWABLE LEAKAGE INWARD OR OUTWARD (INFILTRATION OR EXFILTRATION) FOR ANY SANITARY SEWER SECTION TESTED, INCLUDING ALL MANHOLES, IS 200 GALLONS PER INCH OF DIAMETER PER MILE OF PIPE PER DAY. MANHOLES MAY BE TESTED SEPARATELY. THE ABOVE ALLOWABLE LEAKAGE RATE IS EQUIVALENT TO 0.16 GALLONS PER INCH OF DIAMETER PER 100 FEET OF PIPE PER HOUR.

9. MANHOLE TOP ELEVATIONS AS INDICATED ON THE PLAN AND PROFILE SHEETS ARE APPROXIMATE AND ARE TO BE USED FOR BIDDING PURPOSES ONLY. ACTUAL TOP ELEVATIONS WILL BE FIELD DETERMINED AT THE TIME OF CONSTRUCTION. NO INCREASE OR REDUCTION IN BID PRICE WILL BE MADE FOR MANHOLES WHOSE AS-BUILT DEPTHS VARY FROM THOSE SHOWN ON THE PLANS.

10. SERVICE CONNECTION LOCATIONS MAY VARY DEPENDING ON FIELD CONDITIONS. FIELD LOCATIONS SHALL BE AS DIRECTED BY THE ENGINEER OR HIS AGENT.

11. PRIOR TO THE START OF WORK ON THE SANITARY SEWER ON SLEEPY HOLLOW ROAD, THE CONTRACTOR SHALL OBTAIN A "HIGHWAY USE PERMIT" FROM THE MEDINA COUNTY ENGINEER AT 791 WEST SMITH ROAD, MEDINA, OHIO. THIS PERMIT IS SIMILAR TO THE ODOT PERMIT AND REQUIRES THE PAYMENT OF A FEE.

12. PAYMENT FOR ALL OF THE ABOVE WILL BE INCLUDED IN THE CONTRACT UNIT PRICE BID PER LINEAR FOOT OF 8" OR 15" SANITARY SEWER AS PER PLAN.

## SANITARY SEWER AS-BUILT DRAWINGS

UPON COMPLETION OF THE CONSTRUCTION OF THE SANITARY SEWER ALONG SLEEPY HOLLOW ROAD, THE STATE SHALL PROVIDE "AS-BUILT" DRAWINGS TO THE MEDINA COUNTY SANITARY ENGINEERING DEPARTMENT. THE STATE SHALL ALSO COMPLETE A "SANITARY MANHOLE CASTING AS-BUILTS" CHART WHICH MUST BE CERTIFIED BY AN ENGINEER OR SURVEYOR.


# NOTES

## MISCELLANEOUS

FOR ADDITIONAL NOTES, PAY ITEMS AND DESCRIPTIONS, SEE VARIOUS SPECIALTY ITEM SHEETS THROUGHOUT THE PLANS.

## ITEM 608 - 4" CONCRETE WALK, AS PER PLAN

Subgrade under 4" concrete walks shall be compacted to a depth of 4 inches as described in 203.13. Excavation for the 4 inches of subgrade compaction shall be included in the Lump Sum price bid for Item 203 - Excavation Not Including Embankment Construction. Embankment for walk areas shall be included in the Lump Sum price bid for Item 203 - Embankment.

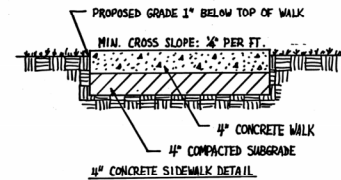

Note: For details of 6" concrete entrance walks to Motorist Services Building see sheet No. 25.

## ITEM SPECIAL - ALTERNATE SHELTER HOUSE DESIGN - "SHELTER HOUSE WITH SHINGLED ROOF"

THE CONTRACTOR MAY PROVIDE AN "IRON MOUNTAIN FORGE - PARK SHELTER" (AS MODIFIED BELOW) OR EQUAL AS A SHELTER HOUSE ON THIS PROJECT.

THE SHELTER HOUSE SHALL HAVE A MINIMUM SIZE OF 20' x 26' (ALT 20' x 28') AND SHALL BE MANUFACTURED FROM KILN-DRIED SOUTHERN PINE. THE STRUCTURAL, GLUED LAMINATED TIMBER SHALL CONFORM TO THE FOLLOWING SPECIFICATIONS: AITC-100, 117, 177, 200 AND PS-56-73. A CERTIFICATE OF CONFORMANCE SHALL BE FURNISHED AND THE AITC QUALITY MARK SHALL APPEAR ON ALL LAMINATED MEMBERS. THE ADHESIVE SHALL BE WATER-PROOF AND CONFIRMING TO ASTM D-2559-70. THE ROOF DECK SHALL BE NOMINAL 2" x 6" AND BTR, SINGLE TONGUE AND GROOVE WITH V-JOINT FACE SIDE AND SHALL BE FACTORY FINISHED WITH A POTLATCH ACRYLIC POLYMER IN EARTH TONE. THE ASPHALT SHINGLE ROOF SHALL CONFORM TO STD. DRW. LA-16.

THE ROOF SYSTEM SHALL, IN ADDITION TO THE MANUFACTURERS LOADING, BE ABLE TO WITHSTAND 90 MPH WIND LOADS IN CONFORMANCE WITH ARTICLE 9 (OAC 4101: 2-9) OF THE OHIO BASIC BUILDING CODE. THE FABRICATOR SHALL FURNISH COMPLETE SHOP DRAWINGS, SHOWING ALL DETAILS AND CONNECTIONS OF THE COLUMNS AND ROOF SYSTEM, AS WELL AS CALCULATIONS VERIFYING THAT THE SYSTEM SATISFIES THE OHIO BUILDING CODE ARTICLE.

ALL MEMBERS SHALL BE INDIVIDUALLY WRAPPED FOR PROTECTION DURING SHIPPING AND STORAGE. THE COLUMNS AND FACIA SHALL BE TREATED BY THE CELLON (R) PROCESS IN ACCORDANCE WITH STD C-28 AWWA TO A RETENTION OF 0.6 # PER CU. FT. THE CONTRACTOR SHALL PROTECT THE SHELTER HOUSE MATERIALS ON THE JOB SITE. IF STORED TEMPORARILY, MEMBERS SHALL BE PLACED ON BLOCKS WELL OFF THE GROUND AND SEPARATED BY WOOD STRIPS SO THAT AIR CAN CIRCULATE AROUND EACH MEMBER. THE TOP AND BOTTOM SHALL BE COVERED WITH MOISTURE-RESISTANT PAPER. ALL ERECTION WORK SHALL BE PERFORMED USING NON-MARRING SLINGS WHEN MEMBERS ARE TO BE HANDLED.

## PERMITS AND FEES

SEE SHT. NO. 2 OF PART II.

MEDINA COUNTY  
MED-71-22.14 (S.B.)  
IR-71-4(57)224 PART I

| F. H. W. A. | STATE | PROJECT      |
|-------------|-------|--------------|
| REGION      | OHIO  | MED-71-22.14 |
| 5           |       |              |




3  
47

| DESIGNED BY | DATE |
|-------------|------|
| MA G        | 8/84 |
| CHECKED BY  | DATE |
| T. O.       | 8/84 |


## SEEDING, SODDING AND TOPSOIL

To establish a good lawn in areas not covered under specific pay items such as 603 - Storm & Sanitary Sewers and 625 - Electrical Conduits & Cables, when directed by the Engineer, approved topsoil shall be spread 3" deep over all bare or disturbed soil and the lawn areas sodded or seeded. (See sheet No. 9 for estimated quantities.)

Finish grading shall be adjusted where necessary to maintain proper ground line where topsoil and sod are required.

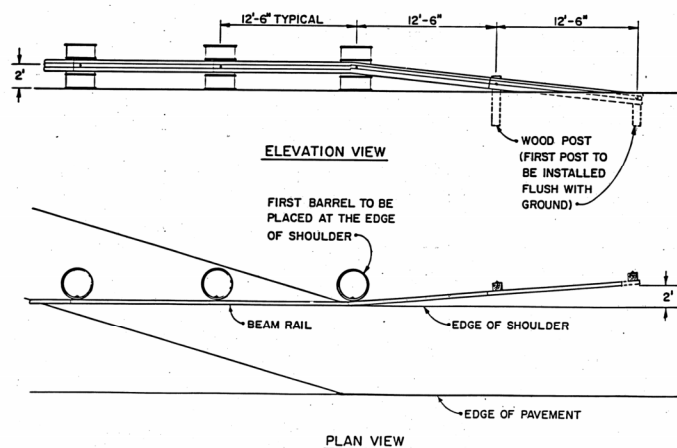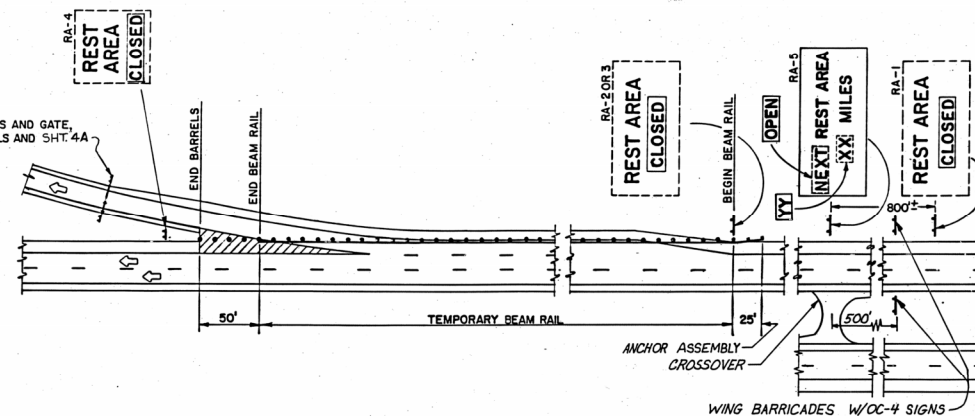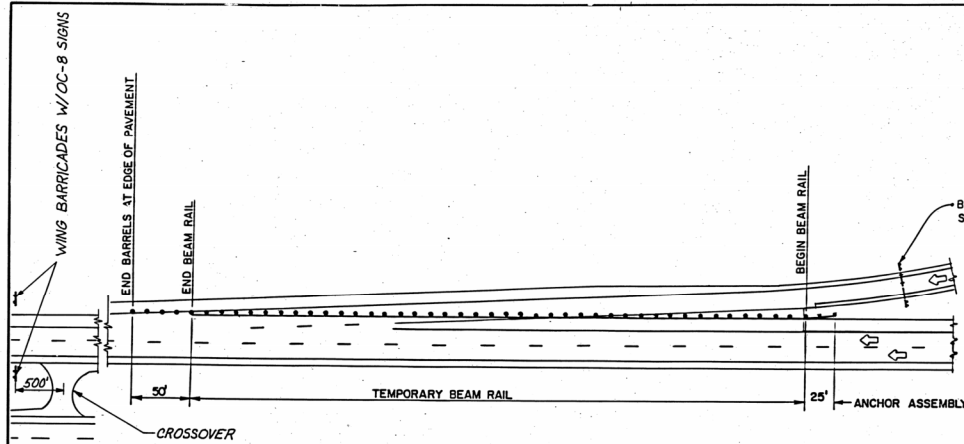

TEMPORARY ANCHOR ASSEMBLY

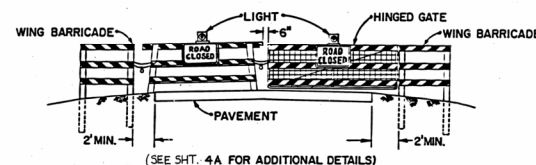

BARRICADES AND GATE

NOTES:

- REST AREA SIGNS (RA-1 THRU RA-4) SHALL HAVE THE ACTION MESSAGE COVERED BY AN OVERLAY BEARING THE LEGEND "CLOSED". THIS PANEL SHALL HAVE A BLACK LEGEND ON A REFLECTORIZED ORANGE BACKGROUND. THE OVERLAY FOR THE RA-1, RA-2 AND RA-3 SIGNS SHALL BE 8' X 1 1/2'. THE OVERLAY FOR THE RA-4 SIGNS SHALL BE 4' X 1 1/2'.
- SUPPLEMENTAL PANELS LOCATED UNDER MAINLINE REST AREA SIGNS SHALL BE REMOVED OR COVERED WHEN THE REST AREA IS CLOSED. (EXAMPLE: TELEPHONE, TOURIST INFO, HANDICAPPED SYMBOL SIGN).
- TEMPORARY BEAM RAIL, IN ACCORDANCE WITH ODOT CONSTRUCTION AND MATERIAL SPECIFICATION 606.04, SHALL BE USED TO CLOSE THE ACCELERATION AND DECELERATION LANES FOR REST AREA CLOSURES EXCEEDING 7 DAYS. (FOR DETAILS ON ANCHOR ASSEMBLIES AND GUARDRAIL FLARES, SEE TEMPORARY ANCHOR ASSEMBLY DETAIL.) FOR REST AREA CLOSURES OF LESS THAN 7 DAYS, THE DECELERATION AND ACCELERATION LANES SHOULD BE CLOSED WITH REFLECTORIZED DRUMS PLACED 15' CENTER TO CENTER. THE EXISTING SHOULDER WIDTH SHALL BE MAINTAINED AT ALL TIMES. TEMPORARY CONCRETE BARRIER WITH END TERMINALS IN ACCORDANCE WITH MC-9A MAY BE USED AS AN ALTERNATE TO THE TEMPORARY BEAM RAIL AND ANCHOR ASSEMBLY.
- WHERE REST AREA RAMP LIGHTING EXISTS, IT SHALL BE MAINTAINED IN PROPER CONDITION TO PROVIDE OPTIMUM ILLUMINATION.
- REST AREA SIGN RA-5 SHALL BE ADDED WITH PROPER MILEAGE SHOWN. DURING CLOSURE THE WORDS "OPEN" AND APPLICABLE MILEAGE SHALL BE ADDED WITH BLACK ON ORANGE OVERLAYS. THE OVERLAY SIZE IS 3 1/2' X 1 1/2'. LOCATION TO BE APPROVED BY THE ENGINEER.
- GATES AND BARRICADES, IN ACCORDANCE WITH SHTA-4 SHALL BE ERECTED ACROSS THE EXIT AND ENTRANCE RAMP FOR THE REST AREA.

ESTIMATED QUANTITIES FOR EXTRU-SHEET SIGNS TO BE INCLUDED IN THE GENERAL SUMMARY, SHEET 5



| ITEM | DESCRIPTION                      | UNIT    | QUANT. |
|------|----------------------------------|---------|--------|
| 630  | SIGN, EXTRU-SHEET TYPE G         | SQ. FT. | 58.5   |
| 630  | GROUND MOUNTED SUPPORT, W10X11.5 | L.F.    | 36     |
| 630  | CONCRETE FOR EMBEDDED FOUNDATION | C.Y.    | 2.2    |
| 630  | BREAKAWAY BEAM CONNECTIONS       | E.A.    | 2      |

THESE ITEMS AND QUANTITIES SHALL BE FIELD CHECKED AND APPROVED BY THE ENGINEER.


7. THE FOLLOWING MILEAGES SHALL BE INCLUDED ON THE RA-5 SIGNS ON THIS PROJECT:

|         |                   |    |
|---------|-------------------|----|
| SB RA-5 | PERMANENT MILEAGE | 27 |
| RA-5    | TEMPORARY MILEAGE | 27 |
| RA-5    | PERMANENT MILEAGE |    |
| RA-5    | TEMPORARY MILEAGE |    |

## MOVABLE GATE

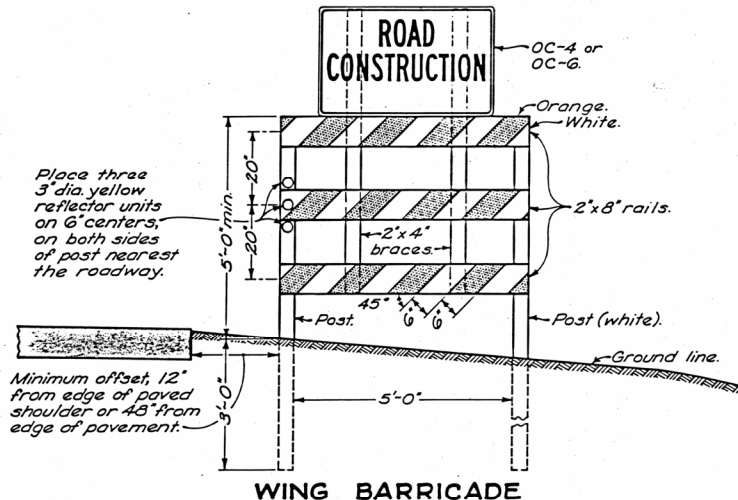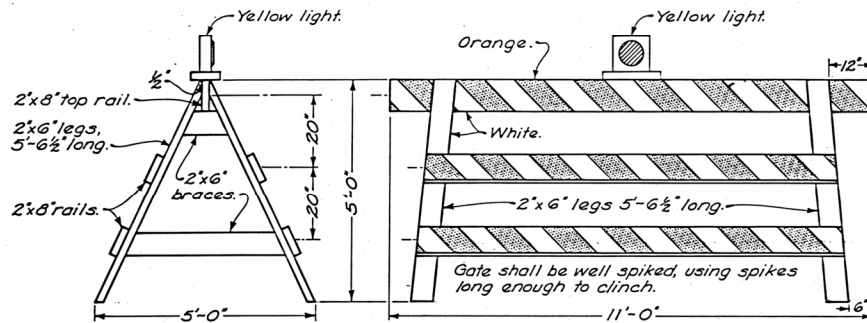

WING BARRICADE

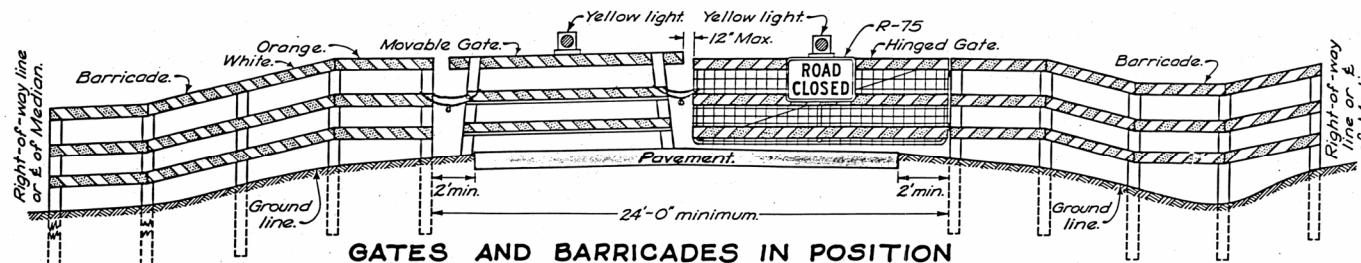

GATES AND BARRICADES IN POSITION

## NOTES

| FED. RD. DIVISION | STATE | PROJECT       |
|-------------------|-------|---------------|
| 5                 | OHIO  | MED.-71-22.14 |

4A  
47

**BARRICADES** shall be constructed according to details shown. Where traffic is maintained during construction, wing barricades shall be used on each shoulder: (1) at both ends of the project, (2) on all interchange entrance ramps or on the cross road preceding the entrance ramp, (3) on all other major approach roads as directed by the Engineer. When the road is closed to traffic, barricades and gates shall be used to effectively close the entire roadway including the median of divided highways. In urban areas and at locations where it is impracticable to extend the barricade to the right-of-way line because of a sidewalk or other obstruction, the ends of the barricade shall be located as directed by the Engineer to effect the desired closing of the highway.

**PAINTING AND REFLECTORIZATION:** All rails of the barricades and gates shall be reflectorized with orange and white reflectorized sheeting in 6" wide alternate stripes which slope downward toward the center line of the road at an angle of 45°. All three rails of the Road Closed barricade shall be striped on the side facing traffic. All three rails of the wing barricade and all gate rails shall be striped on both sides. All posts, braces, gate legs and any unstriped rails shall be painted white.

**GATES:** One gate shall be erected for each traffic lane. Gates shall be chained and padlocked to one another and to adjacent posts of the barricades. Chains shall be 1/2" stock or larger with welded links.

A hinged gate may be used and shall be an approved 12" by 4" steel frame type, or a type approved by the Engineer. The gate shall be hung on hinge screw hooks, or as otherwise approved. Striping similar to that used on the movable gate shall be accomplished with 1"x8" lumber or with metal strips fastened to the gate. The gate shall be supported at the center in an approved manner.

**YELLOW LIGHT:** Each gate shall be equipped with a steady burning yellow light, conspicuously visible at all distances up to 1000' under normal atmospheric conditions. The light, operated by battery, electric generator, commercial power or propane gas, shall be in operation at all times between sunset and sunrise during the period the highway is closed.

**SIGNS:** Where the road is closed to traffic by the erection of gates and barricades, a **ROAD CLOSED** sign (R-75) shall be mounted on the gate as shown. On three-lane pavement, the sign shall be mounted on the middle gate facing traffic.

Where traffic is maintained, a **ROAD CONSTRUCTION TRAFFIC MAINTAINED** sign (OC-4) shall be used on the right shoulder wing barricade on the approaches to major construction or maintenance jobs less than 2 miles in length. A **ROAD CONSTRUCTION NEXT MILES** sign (OC-6) shall be used on the right shoulder wing barricade on the approaches to any major construction or maintenance job of 2 miles or more in length. An **END CONSTRUCTION** sign (OC-8) shall be erected above the right hand wing barricade facing traffic leaving the construction section. The signs on the wing barricades shall be erected above the top rail of the wing barricade on braces, as detailed hereon.

**LUMBER** used in the construction of the gates and barricades shall be No. 1 common yellow pine or No. 1 common Douglas fir, surfaced on four sides standard, or other materials approved by the Engineer. All sizes are nominal.

**POSTS** shall be sound 4"x4" sawed or 4 1/2" round. Rails of the barricade shall be bolted to the posts with 5/8" bolts.

|         |          |             |               |
|---------|----------|-------------|---------------|
|         | BY DATE  |             |               |
| CALC    | MAR 3/84 | FWHA REGION | STATE PROJECT |
| CHECKED | JLO 2/94 | 5 OHIO      | MED-71-22.14  |

MEDINA COUNTY  
 MED-71-22.14 (S.B.)  
 IR-71-4(57)224 PART I

5  
47

## GENERAL SUMMARY



|                   |           |                                                               |  |       |              |                                                                                     |
|-------------------|-----------|---------------------------------------------------------------|--|-------|--------------|-------------------------------------------------------------------------------------|
| BY DATE           |           | FHWA REGION                                                   |  | STATE | PROJECT      |  |
| CALC.             | MHS 12/84 | 5                                                             |  | OHIO  | MED-71-22.14 |                                                                                     |
| CHECKED JCO 12/84 |           | MEDINA COUNTY<br>MED-71-22.14 (S.B.)<br>IR-71-4(57)224 PART I |  |       |              |                                                                                     |

## GENERAL SUMMARY

|         |     |      |        |       |              |  |
|---------|-----|------|--------|-------|--------------|--|
| CALC.   | BY  | DATE | FWHA   | STATE | PROJECT      |  |
|         | MHC | 8/84 | REGION |       |              |  |
| CHECKED | JLO | 8/94 | 5      | OHIO  | MED-71-22.14 |  |

7

47

MEDINA COUNTY  
MED - 71-22.14 (S.B.)  
IR - 71-4(57)224 PART I

## GENERAL SUMMARY

SM-1  
CONST. MANHOLE MOD. AS PER PLAN  
STA. 43+57.97' LT. @ S.B. REST AREA  
INV. 1111.25 - 8" N.E. & S.E.  
TOP 1116.00


 
CB-1  
CONST. STD. No 2-28 C.B.  
STA. 43+75.95' LT. @ S.B. REST AREA  
INV. 1111.90 - 8" S.W.  
INV. 1112.07 - 6" S.E.  
INV. 1112.34 - 4" S.E.  
INV. 1112.60 E  
TOP 1114.25

CALC. BY DATE  
CHECKED #15 B/29  
11/20/14

F.H.W.A. STATE PROJECT  
5 OHIO MED-71-22.14

MEDINA COUNTY  
MED-71-22.14 (S.B.)  
IR-71-4(57)224 PART I

8  
47

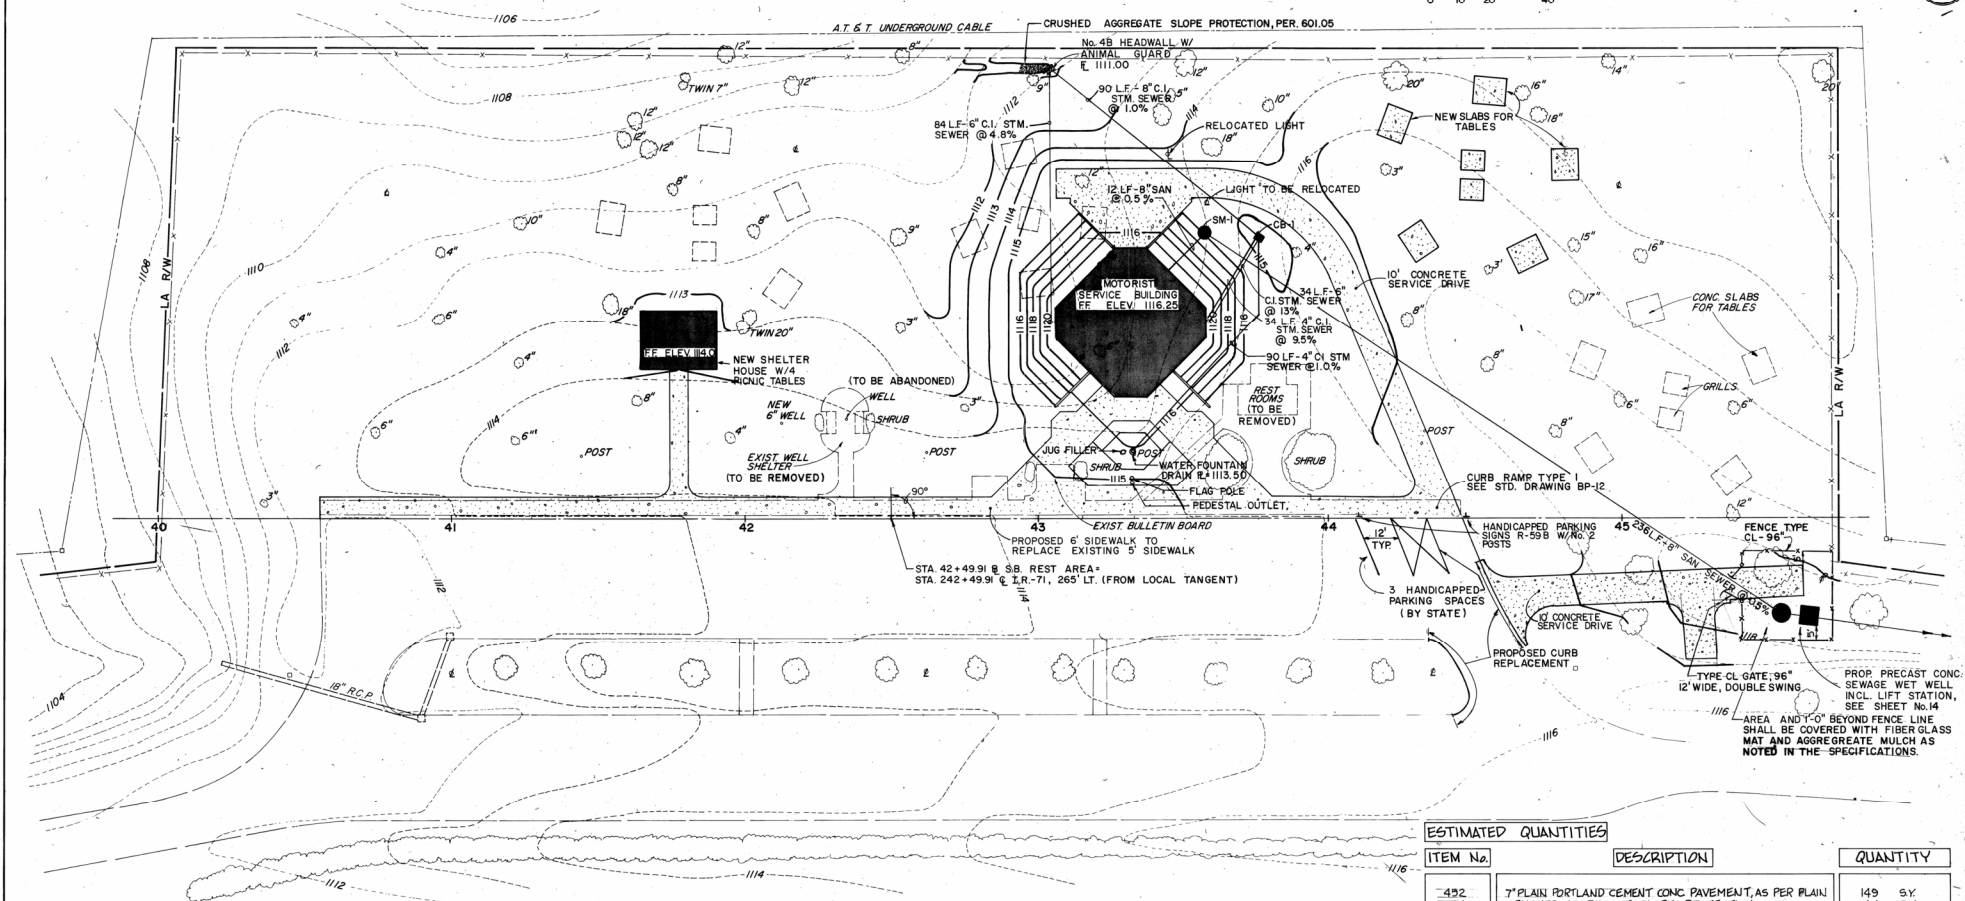



NOTE: FOR STORM AND SANITARY  
SEWER PROFILES SEE SHEET No. 14

ESTIMATED QUANTITIES

| ITEM No. | DESCRIPTION                                                      | QUANTITY |
|----------|------------------------------------------------------------------|----------|
| 492      | 7" PLAIN PORTLAND CEMENT CONC. PAVEMENT, AS PER PLAN             | 149 SY   |
| 601      | CRUSHED AGGREGATE SLOPE PROTECTION                               | 44 SY    |
| 602      | STANDARD HW-4B HEADWALL W/ANIMAL GUARD                           | 0.2 CY   |
| 603      | 4" DUCTILE CAST IRON PIPE, AS PER PLAN                           | 124 L.F. |
| 118      | 6" DUCTILE CAST IRON PIPE, AS PER PLAN                           | 118 L.F. |
| 603      | 8" DUCTILE CAST IRON PIPE, AS PER PLAN                           | 90 L.F.  |
| 603      | 8" SANITARY SEWER AS PER PLAN                                    | 245 L.F. |
| 604      | MANHOLE, MODIFIED AS PER PLAN                                    | 1 EACH   |
| 604      | STANDARD 2-28 CATCH BASIN                                        | 1 EACH   |
| 607      | FENCE, TYPE CL (30')                                             | 108 L.F. |
| 607      | GATE, TYPE CL 12" WIDE, DOUBLE SWING (30')                       | 1 EACH   |
| 600      | SIGNS, FLAT SHEETS                                               | 5 S.F.   |
| 600      | GROUND MOUNTED SUPPORTS, No. 2 POSTS                             | 25 L.F.  |
| SPEC.    | SHELTER HOUSE WITH ASPHALT SHINGLE ROOF                          | 1 EACH   |
| SPEC.    | PICNIC TABLES                                                    | 18 EACH  |
| SPEC.    | REST AREA RESERVOIR ASSEMBLY (EXCEPT ELECTRICAL & PLUMBING WORK) | 1 EACH   |
| SPEC.    | NON-WOVEN FIBER MAT AND MULCH, AS PER PLAN                       | 80 SY    |

BENCH MARK:  
CHISELED "+" @ S.E. CORNER OF INLET @ S.B.  
REST AREA @ STA. 41+00, 40' RT.  
ELEV. = 1112.56

 SITE PLAN - SOUTHBOUND

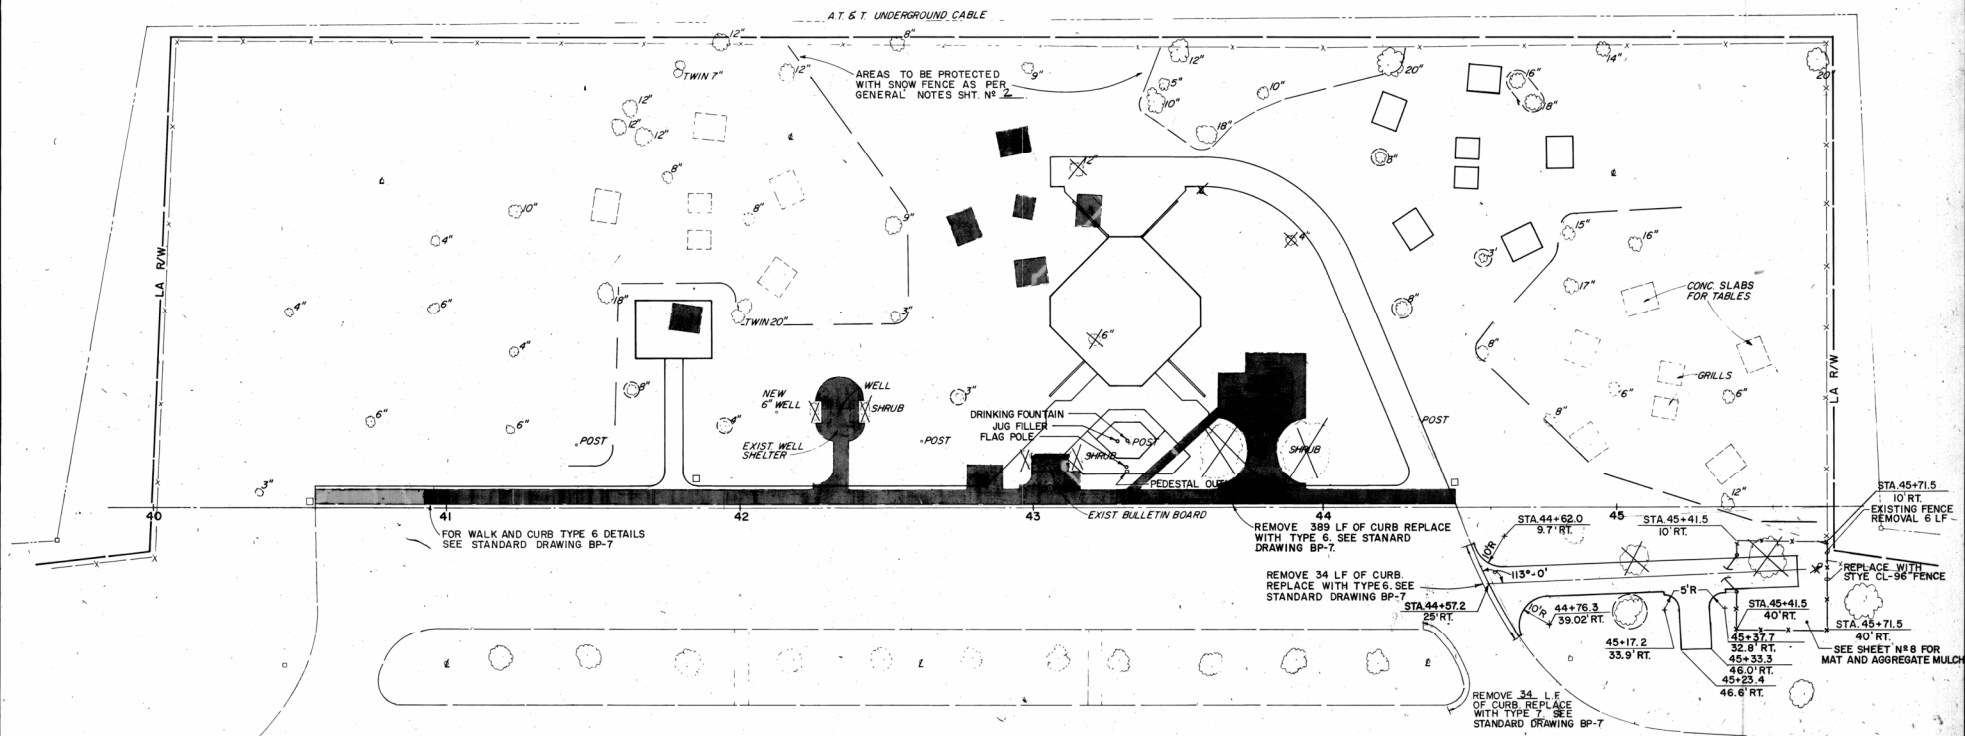

### LEGEND

- ITEMS TO BE REMOVED
- AREAS TO BE PROTECTED WITH SNOW FENCE AS PER GENERAL NOTES SHT. NO. 2
- WASTE RECEPTACLE WITH SLAB
- LOCATION AS DIRECTED BY ENGINEER
- POST & SIGN (TO BE REMOVED BY STATE)
- Seeding, sodding and topsoil furnished and placed as directed by the Engineer. (See note on Sheet No. 3)
- NEW TREES TO BE PLANTED AS DIRECTED BY THE HORTICULTURIST

| ITEM NO.                | DESCRIPTION                                                                     | QUANTITY   |
|-------------------------|---------------------------------------------------------------------------------|------------|
| <b>GENERAL CONTRACT</b> |                                                                                 |            |
| 663                     | ACER RUBRUM 'RED SUNSET' - RED SUNSET RED MAPLE 3'-3 1/2" CAL. B & B 38"        | 3 EACH     |
| 663                     | LIQUIDAMBAR STYRACIFLUA 'MORAINE' - MORAINES SWEET GUM 3'-3 1/2" CAL. B & B 38" | 3 EACH     |
| 663                     | QUERCUS RUBRA MAXIMA - EASTERN RED OAK 3'-3 1/2" CAL. B & B 38"                 | 3 EACH     |
| 663                     | QUERCUS PHellos - WILLOW OAK 3'-3 1/2" CAL. B & B 38"                           | 3 EACH     |
| 202                     | FENCE REMOVED                                                                   | 6          |
| 201                     | DRILLED WATER WELL, ABANDONED                                                   | 1 EACH     |
| 202                     | CLEARING & GRUBBING                                                             | 1987 S.F.  |
| 202                     | STRUCTURES REMOVED                                                              | 1950 S.F.  |
| 202                     | PRIVY VAULT REMOVED, AS PER PLAN                                                | 457 L.F.   |
| 202                     | WALK REMOVED                                                                    | 2209 S.F.  |
| 202                     | WALK REMOVED (WALK ADJACENT TO PARKING LOT ONLY)                                | 423 L.F.   |
| 609                     | CURB, TYPE 6                                                                    | 34 L.F.    |
| 609                     | CURB, TYPE 7                                                                    | 5 EACH     |
| SPEC.                   | CONCRETE SLAB FOR PICNIC TABLE                                                  | 760 L.F.   |
| SPEC.                   | SNOW FENCE (FOR TREE PROTECTION)                                                | 18 EACH    |
| * SPEC.                 | WASTE RECEPTACLE SLEEVE                                                         | 16 EACH    |
| * SPEC.                 | WASTE RECEPTACLE SLAB                                                           | 2 EACH     |
| Δ 659                   | SEEDING & MULCHING                                                              | 2000 S.Y.  |
| Δ 659                   | COMMERCIAL FERTILIZER                                                           | 0.32 TON   |
| Δ 660                   | SODDING, AS PER PLAN                                                            | 1,600 S.Y. |
| Δ 663                   | TOPSOIL FURNISHED AND PLACED                                                    | 300 C.Y.   |

 
REMOVAL AND TREE PROTECTION PLAN - SOUTHBOUND

| F. H. W. A.<br>REGION | STATE | PROJECT      |
|-----------------------|-------|--------------|
| 5                     | OHIO  | MED-71-22.14 |

10  
47

MEDINA COUNTY  
MED-71-22.14 (S.B.)  
IR-71-4(57)224 PART I

CALC. BY DATE  
CHECKED /JRO/ 8/84




PROPOSED SERVICE  
DRIVE 10' WIDE

CURB RAMP  
STANDARD TYPE I  
SEE STD. DRWG. BP-12

# ESTIMATED QUANTITIES

| ITEM No.         | DESCRIPTION                                                                                    | QUANTITY  |
|------------------|------------------------------------------------------------------------------------------------|-----------|
| GENERAL CONTRACT |                                                                                                |           |
| 452              | 7" PLAIN PORTLAND CEMENT CONCRETE PAVEMENT, AS PER PLAN                                        | 302 S.Y.  |
| 608              | 4" CONCRETE WALK (DOES NOT INCLUDE WALK ADJACENT TO PARKING LOT)                               | 1809 S.F. |
| 608              | CURB RAMP, STANDARD TYPE I                                                                     | 1 EACH    |
| SPEC.            | MOTORIST SERVICES BUILDING & STORAGE UNIT (EXCEPT ELECTRICAL, PLUMBING, HEATING & VENTILATING) | 1 EACH    |

LAYOUT PLAN - SOUTHBOUND


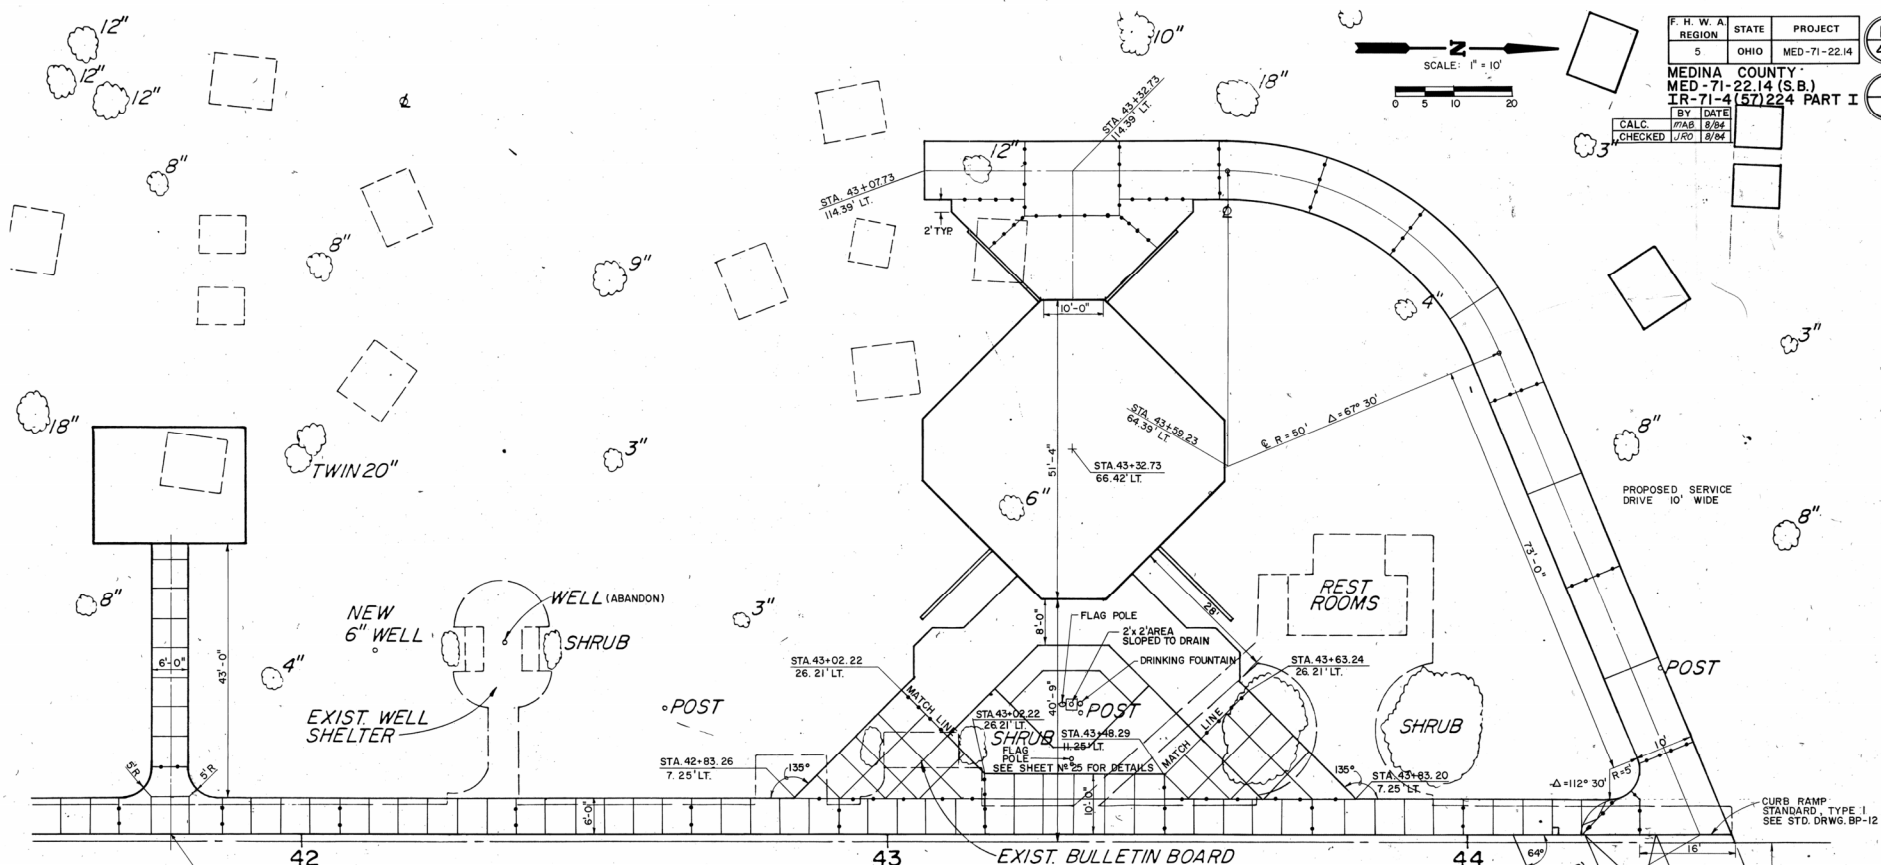


NOTE: BEGIN NEW 6' WALK  
@ STA. 40+55, END @ STA. 44+25  
SIDEWALK FOR PICNIC SHELTER  
STA. 41+775, 125' LT.

| F.H.W.A. | STATE | PROJECT      |
|----------|-------|--------------|
| 5        | OHIO  | MED-71-22.14 |

11  
47

 MEDINA COUNTY  
MED-71-22.14 (S.B.)  
IR-71-4(57)224 PART I

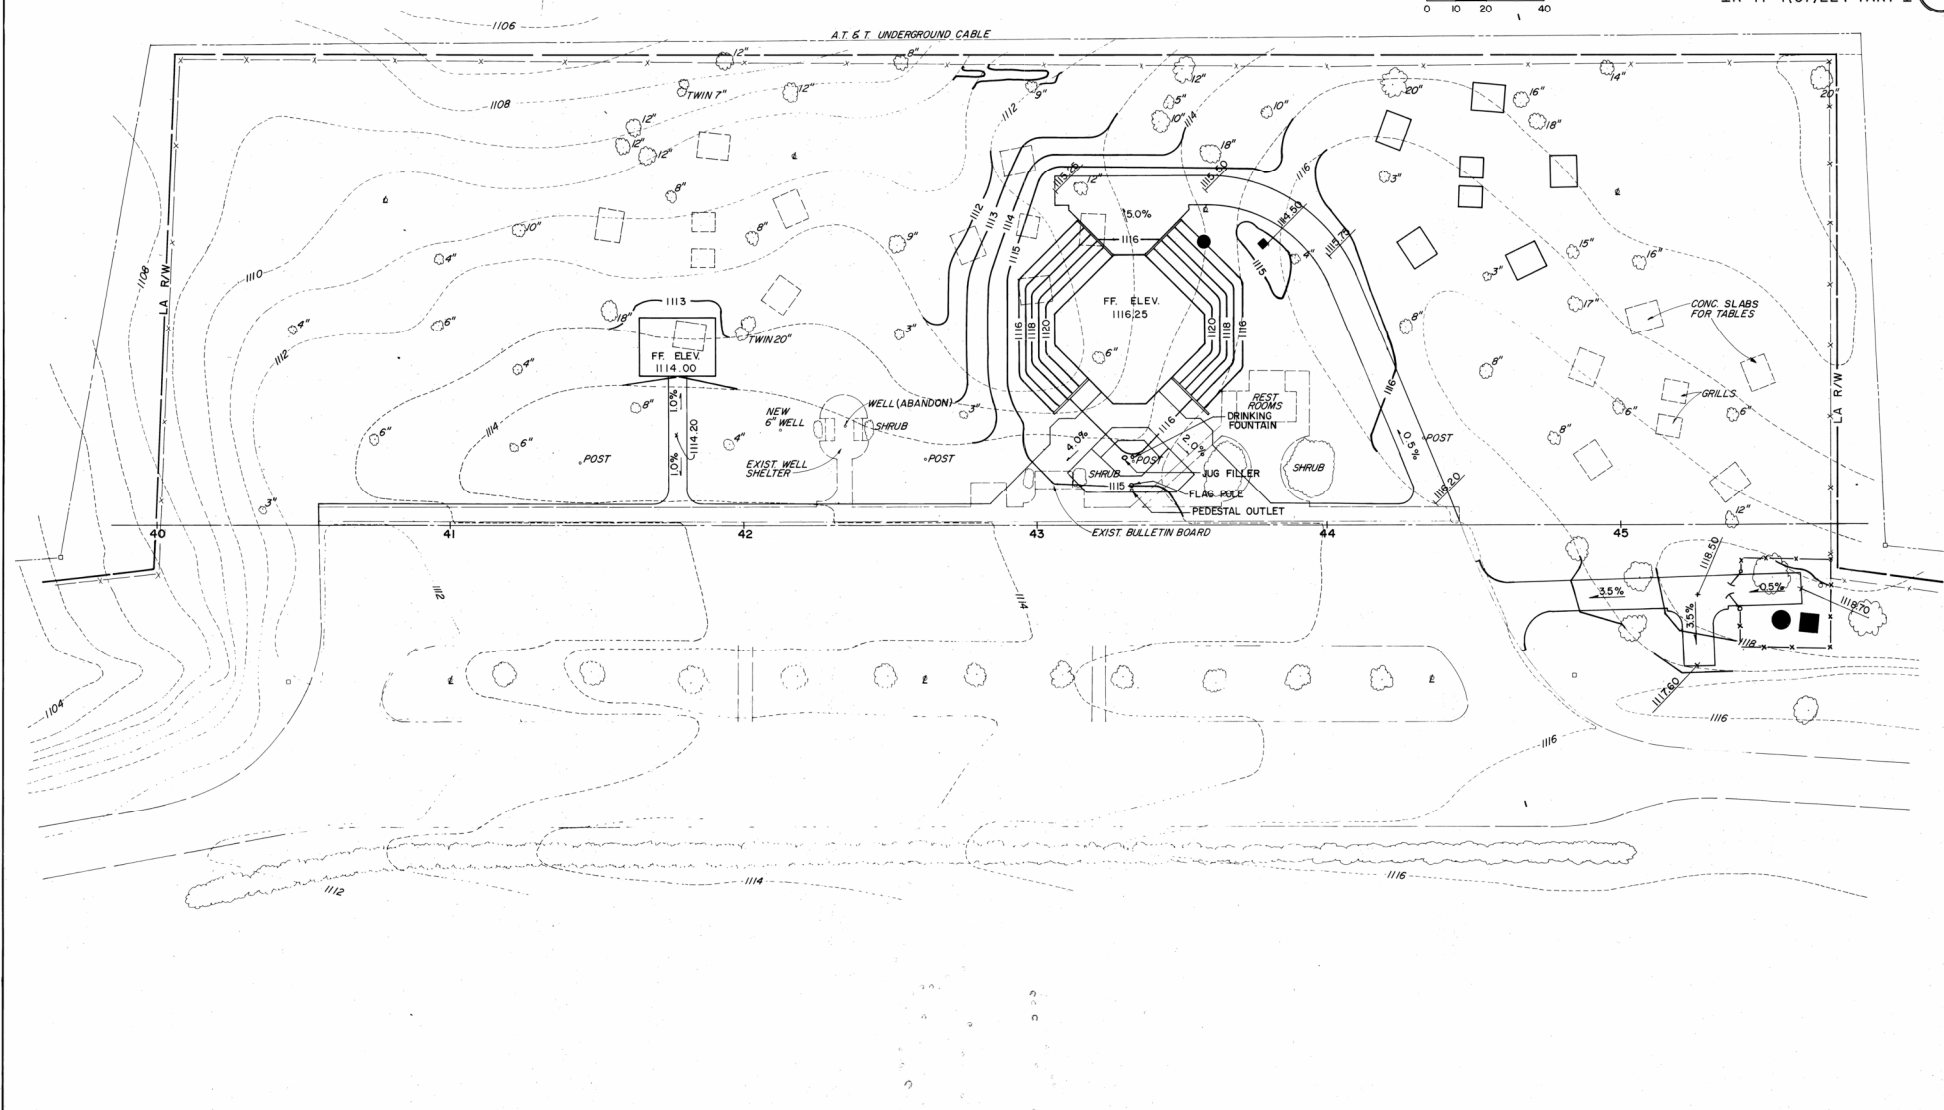



GRADING PLAN - SOUTHBOUND




| BY      | DATE    | F.H.W.A. | STATE | PROJECT      |
|---------|---------|----------|-------|--------------|
| CALC.   | 1/28/84 | 5        | OHIO  | MED-71-22.14 |
| CHECKED | 1/30/84 |          |       |              |

12  
47

 MEDINA COUNTY  
MED-71-22.14 (S.B.)  
IR-71-4(57)224 PART I

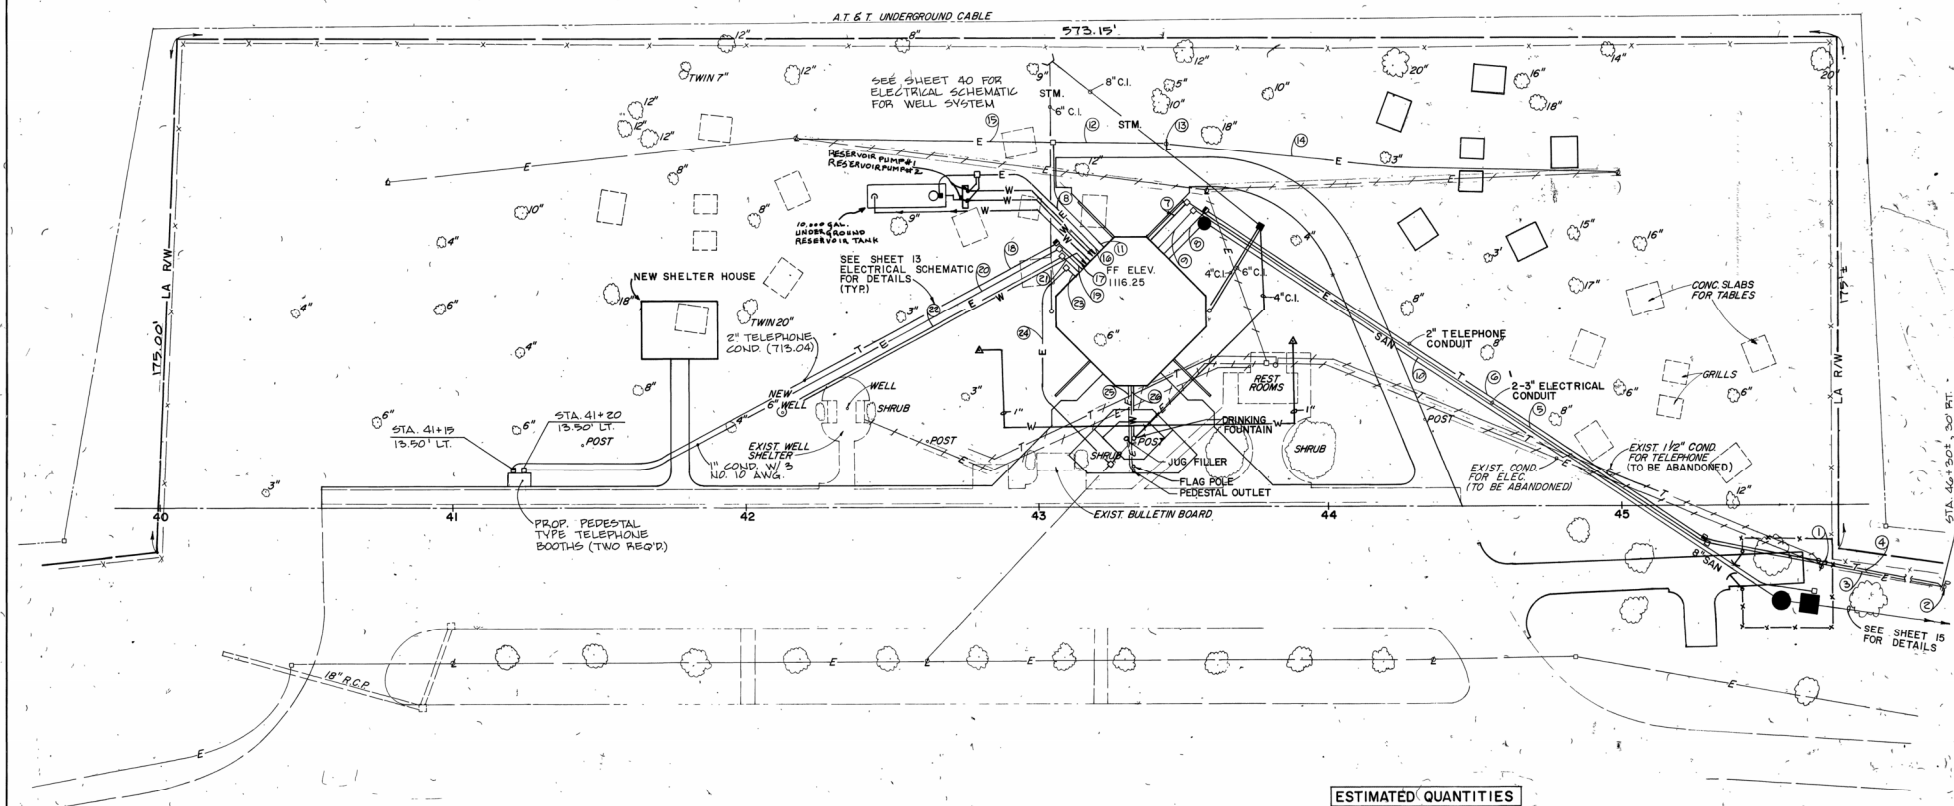

#### UTILITY TRENCH DETAIL

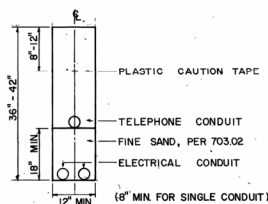

△- Flush box hydrant with Watts No. 8 vacuum breaker & key, Mardock Cat. No. V-477-34" bronze box and lid, with brass pipe, 4 ft. long, anti-freezing. Approved equal by Wade, Josam or Zurn. (See Sheets No. 25 & 31 for drinking fountain & jug filler.)

#### LEGEND

|     |                                                       |
|-----|-------------------------------------------------------|
| PE  | PRIMARY ELECTRIC                                      |
| SE  | SECONDARY ELECTRIC                                    |
| E   | EXTERIOR CIRCUITS (ELECTRIC)                          |
| T   | TELEPHONE                                             |
| W   | WATER                                                 |
| SAN | SANITARY SEWERS                                       |
| STM | STORM SEWER                                           |
| □   | PULL BOX - ELECTRIC                                   |
| ■   | PULL BOX - TELEPHONE                                  |
| ●   | MANHOLE                                               |
| ○   | CATCH BASIN                                           |
| ⋈   | EXISTING TERMINATION POLE                             |
| ⋈   | EXISTING LIGHT POLES CONDUIT OR CABLE TO BE ABANDONED |
| △   | FLUSH BOX HYDRANT (SEE NOTE THIS SHEET)               |

#### ESTIMATED QUANTITIES

| ITEM No.                                  | DESCRIPTION                                                        | QUANTITY    |
|-------------------------------------------|--------------------------------------------------------------------|-------------|
| <b>ELECTRICAL CONTRACT</b>                |                                                                    |             |
| SPEC.                                     | MOTORIST SERVICES BUILDING & STORAGE UNIT (ELECT. WORK ONLY)       | 1 EACH      |
| SPEC.                                     | WATER WELL ASSEMBLY (ELECT. WORK ONLY)                             | 1 EACH      |
| SPEC.                                     | WATER SYSTEM HYPOCHLORINATOR (ELECT. WORK ONLY)                    | 1 EACH      |
| SPEC.                                     | REST AREA RESERVOIR ASSEMBLY (ELECT. WORK ONLY)                    | 1 EACH      |
| SPEC.                                     | LIFT STATION (ELECT. WORK ONLY)                                    | 1 EACH      |
| <b>PLUMBING CONTRACT</b>                  |                                                                    |             |
| SPEC.                                     | MOTORIST SERVICES BUILDING & STORAGE UNIT (PLUMBING WORK ONLY)     | 1 EACH      |
| SPEC.                                     | 1" TYPE "K" COPPER WATER LINE & HYDRANTS                           | 180 LN. FT. |
| SPEC.                                     | WATER WELL ASSEMBLY (EXCEPT ELECT. WORK)                           | 1 EACH      |
| SPEC.                                     | WATER SYSTEM HYPOCHLORINATOR (EXCEPT ELECT. WORK)                  | 1 EACH      |
| SPEC.                                     | REST AREA RESERVOIR ASSEMBLY (PLUMBING WORK ONLY)                  | 1 EACH      |
| SPEC.                                     | LIFT STATION (PLUMBING WORK ONLY)                                  | 1 EACH      |
| <b>HEATING &amp; VENTILATING CONTRACT</b> |                                                                    |             |
| SPEC.                                     | MOTORIST SERVICES BUILDING & STORAGE UNIT (HEAT & VENT. WORK ONLY) | 1 EACH      |

UTILITIES PLAN - SOUTHBOUND

| ITEM | DESCRIPTION                    | QUANTITY |
|------|--------------------------------|----------|
| 425  | 2" CONDUIT, 715.04             | 550 L.F. |
| 426  | 3" CONDUIT, 715.04             | 878 L.F. |
| 427  | 3" CONDUIT, 715.04             | 674 L.F. |
| 428  | 2" CONDUIT, 715.04             | 172 L.F. |
| 429  | NO. 4 AWG, 1/2" TYPE MW-90 DWP | 380 L.F. |
| 430  | 2" CONDUIT, 715.04             | 121 L.F. |
| 431  | 2" CONDUIT, 715.04             | 121 L.F. |
| 432  | 2" CONDUIT, 715.04             | 121 L.F. |
| 500  | 2" CONDUIT, 715.04             | 121 L.F. |

SUB - SUMMARY  
QUANTITIES FROM SHEET 12.

1. Level alarm (to left station).  
2. 1 - 2" conduit with 3 - NO. 10 THHN, 2 - NO. 10 THHN, and HIGH  
1 - 2" conduit with 3 - NO. 10 THHN, 2 - NO. 10 THHN, and HIGH  
(LIGHTING).  
25.1. 1 - 2" conduit with 3 NO. 10 THHN (TO PEDESTAL OUTLET).  
24.1. 1 - 2" conduit AS PER 713.04 WITH 2 NO. 4 AWG, U.L. TYPE  
AM-90 DRY, 5000 VOLT CONDUCTORS AS PER 713.02 (TO RAMP  
LIGHTING).  
23.1. 1 - 2" conduit AS PER 713.04 WITH 2 NO. 4 AWG, U.L. TYPE  
AM-90 DRY, 5000 VOLT CONDUCTORS AS PER 713.02 (TO RAMP  
LIGHTING).  
22.1. 1 - 2" conduit AS PER 713.04 WITH 3 NO. 4 THHN CONDUCTORS AND  
2 B/W LEADS AND 1 NO. 10 THN GROUND WIRE (TO REEL PUMP  
MOTOR).  
21.1. 2 B/W LEADS AND 1 NO. 10 THN GROUND WIRE (TO REEL PUMP  
MOTOR).  
20.1. 1 - 2" conduit AS PER 713.04 WITH 3 NO. 10 THHN (TO PEDESTAL  
TELEPHONE BOOTH).  
19.1. 1 - 2" conduit AS PER 713.04 WITH 3 NO. 10 THHN (TO PEDESTAL  
TELEPHONE).  
18.1. 1 - 2" conduit AS PER 713.04 WITH NO. 12 PULL WIRE  
(TELEPHONE).  
17.1. 1 - 2" conduit AS PER 713.04 WITH NO. 12 PULL WIRE  
(TELEPHONE).  
16.1. 2 B/W LEADS AND 1 NO. 10 THN GROUND (TO RESERVOIR PUMP-3  
START/STOP CONTROL IN RESERVOIR).  
15.1. 1 - 2" conduit AS PER 713.04 WITH 6 NO. 10 AWG CONDUCTORS, 2  
B/W LEADS, 5000 VOLT CONDUCTORS AS PER 713.02 (TO REEL PUMP-3  
LIGHTING).  
14.1. 1 - 2" conduit AS PER 713.04 WITH 2 NO. 4 AWG, U.L. TYPE  
AM-90 DRY, 5000 VOLT CONDUCTORS AS PER 713.02 (TO REEL PUMP-3  
LIGHTING).  
13.1. 1 - 2" conduit AS PER 713.04 WITH 2 NO. 4 AWG, U.L. TYPE  
AM-90 DRY, 5000 VOLT CONDUCTORS AS PER 713.02 (TO REEL PUMP-3  
LIGHTING).  
12.1. 1 - 2" conduit AS PER 713.04 WITH 2 NO. 4 AWG, U.L. TYPE  
AM-90 DRY, 5000 VOLT CONDUCTORS AS PER 713.02 (TO REEL PUMP-3  
LIGHTING).  
11.1. 1 - 2" conduit AS PER 713.04 WITH 2 NO. 4 AWG, U.L. TYPE  
AM-90 DRY, 5000 VOLT CONDUCTORS AS PER 713.02 (TO REEL PUMP-3  
LIGHTING).  
10.1. 1 - 2" conduit with 3 - NO. 10 THHN, 2 - NO. 10 THHN, and HIGH  
LEVEL ALARM (TO LEFT STATION).  
9.1. 1 - 2" conduit with 3 - NO. 10 THHN, 2 - NO. 10 THHN, and HIGH  
LEVEL ALARM (TO LEFT STATION).  
8.1. 1 - 2" conduit with 3 - NO. 10 THHN, 2 - NO. 10 THHN, and HIGH  
LEVEL ALARM (TO LEFT STATION).  
7.1. 1 - 2" conduit with 3 - NO. 10 THHN, 2 - NO. 10 THHN, and HIGH  
LEVEL ALARM (TO LEFT STATION).  
6.1. 1 - 2" conduit with 3 - NO. 10 THHN, 2 - NO. 10 THHN, and HIGH  
LEVEL ALARM (TO LEFT STATION).  
5.1. 1 - 2" conduit with 3 - NO. 10 THHN, 2 - NO. 10 THHN, and HIGH  
LEVEL ALARM (TO LEFT STATION).  
4.1. 1 - 2" conduit with 3 - NO. 10 THHN, 2 - NO. 10 THHN, and HIGH  
LEVEL ALARM (TO LEFT STATION).  
3.1. 1 - 2" conduit with 3 - NO. 10 THHN, 2 - NO. 10 THHN, and HIGH  
LEVEL ALARM (TO LEFT STATION).  
2.1. 1 - 2" conduit with 3 - NO. 10 THHN, 2 - NO. 10 THHN, and HIGH  
LEVEL ALARM (TO LEFT STATION).  
1.1. 1 - 2" conduit with 3 - NO. 10 THHN, 2 - NO. 10 THHN, and HIGH  
LEVEL ALARM (TO LEFT STATION).

|               |  |                     |  |                       |  |
|---------------|--|---------------------|--|-----------------------|--|
| MEDINA COUNTY |  | MED-71-22.14 (S.B.) |  | IR-71-4(57)224 PART I |  |
| F. H. W. A.   |  | REGION              |  | 5                     |  |
| STATE         |  | OHIO                |  | MED-71-22.14          |  |

|             |      |
|-------------|------|
| DESIGNED BY | DATE |
| DRAWN BY    | BY   |
| CHECKED BY  | DATE |

## OUTLET BOXES AND FITTINGS

## NOTES

- F. CABLE SHALL BE SPECIFIED IN INSTALLING WIRES IN CONDUIT SO THAT INSULATION WILL NOT BE DAMAGED. NOTHING EXCEPT APPROVED WIRE LUMINAINT SHALL BE USED TO ASSIST IN WIRE INSTALLATION.
- G. AT EACH OUTLET BOX LEAVE 12 INCHES OF WIRE PROJECTING FOR TAPED CONNECTIONS. EXPOSED ENDS OF WIRES SHALL BE FLEXIBLE STEEL CONDUIT SHALL BE FULL WEIGHT STANDARD INTERLOCKING JOINT TO PERFORM SPECIFICATION UN-566-9

- I. ENDS OF CONDUITS SHALL BE FINISHED TO MEET ALL STANDARDS.
- J. INSURE THE LOCATION OF HEATING AND PLUMBING LINES COMFLICT WITH THE LOCATION OF CONDUITS. THE FORMER SHALL HAVE PREFERENCE.
- K. ALL CONDUITS SHALL BE SMOOTHED FREE OF JOINTS BEFORE WIRE IS INSTALLED.
- L. CONDUITS SHALL BE SIZED IN ACCORDANCE WITH THE NATIONAL ELECTRICAL CODE TO MEET THE NUMBER OF WIRES SHOWN OR REQUIRED.
- M. AIRING SYSTEM
1. MINIMUM WIRE SIZE SHALL BE NO. 12 AWG.
2. HOME RUNS OVER 100 FEET LONG SHALL BE NO. 10 AWG OR LARGER.
- C. THE SPLICING OF WIRES IN OTHER THAN OUTLET OR JUNCTION BOXES IS PROHIBITED.
- D. WIRE WIRES ARE SPliced IN OUTLET BOXES AND WIRE FITTING SHALL BE CAREFULLY MADE, PROPERLY CLEANED, AND SOLDERED AND TAPED WITH SCOTCH NO. 33 ELECTRICAL TAPE.

- [illegible]

- C. CONDUIT DEPOSED OR CRUSHED SHALL NOT BE INSTALLED.
  - B. SHEDS AND OFFICES SHALL BE AVOIDED WHERE POSSIBLE. HOWEVER, WHEN BELONGS ARE NEEDED, AN APPROVED KICKER OR CONDUIT BENDING MACHINE SHALL BE USED.
  - A. CONDUIT SHALL BE MADE OF RIGID STANDARD WEIGHT RIBD STEEL. NOT OVER 60 MIL THICK AND 175.00 PER INCH LENGTH. SHALL BEEN THE 10 LEVEL.
- CONDUIT
- B. UPON COMPLETION OF THE WORK, THE CONTRACTOR SHALL FURNISH THE OWNER A CERTIFICATE OF DISPOSITION AND APPROVAL FROM STATE BUREAU OR AGENCY BEFORE FINAL PAYMENT ON CONTRACT WILL BE ALLOWED.
  - A. INSPECTION.
- INSPECTION.
- AND IS SUBJECT TO THE APPROVAL OF THE DISTRICT ELECTRICAL INSPECTION ASSIGNED BY THE DIVISION OF HIGHWAY AND BUILDING ARTICLES TO COME 1014-210-20 AND 1021. NEAR SUMMARY. NO SHALL CONFORM TO THE REQUIREMENTS OF THE ELECTRICAL

- [illegible]

## ELECTRICAL SPECIFICATIONS

FOR NOTES SEE SHT. 14A



SCALE : 1/2" = 1'-0"



SCALE : 1/2" = 1'-0"



- |                      |       |              |
|----------------------|-------|--------------|
| FED. RD.<br>DIVISION | STATE | PROJECT      |
| 5                    | OHIO  | MED-71-22.14 |
- MEDINA COUNTY  
MED-71-22.14 (S.B.)  
IR-71-4(57)224 PART 1

MEDINA COUNTY  
MED-71-22.14 (S.B.)  
IR-71-4(57)224 PART I

IR-71-4(57)224 PART I



SCALE: 1/2" = 1'-0"



SEWER PROFILE  
FOR DETAILS SEE SHEET N°8




| MANHOLE      | RECONSTRUCTION                   | DETAIL |
|--------------|----------------------------------|--------|
| CONSTRUCT 4" | C.I. INSIDE DROP IN EXISTING 40D |        |
|              | STD. MH-2 MANHOLE                | N.T.S. |


| UTILITY | DETAILS |
|---------|---------|
| 1       | 1       |
| 2       | 2       |
| 3       | 3       |
| 4       | 4       |
| 5       | 5       |
| 6       | 6       |
| 7       | 7       |
| 8       | 8       |
| 9       | 9       |
| 10      | 10      |
| 11      | 11      |
| 12      | 12      |
| 99      | 99      |
| 100     | 100     |



| FROM      | DATE |
|-----------|------|
| PROJECT   |      |
| SURVEY    |      |
| NOTE BOOK |      |
| NO.       |      |

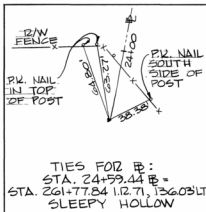

| FROM      | DATE |
|-----------|------|
| PROJECT   |      |
| SURVEY    |      |
| NOTE BOOK |      |
| NO.       |      |

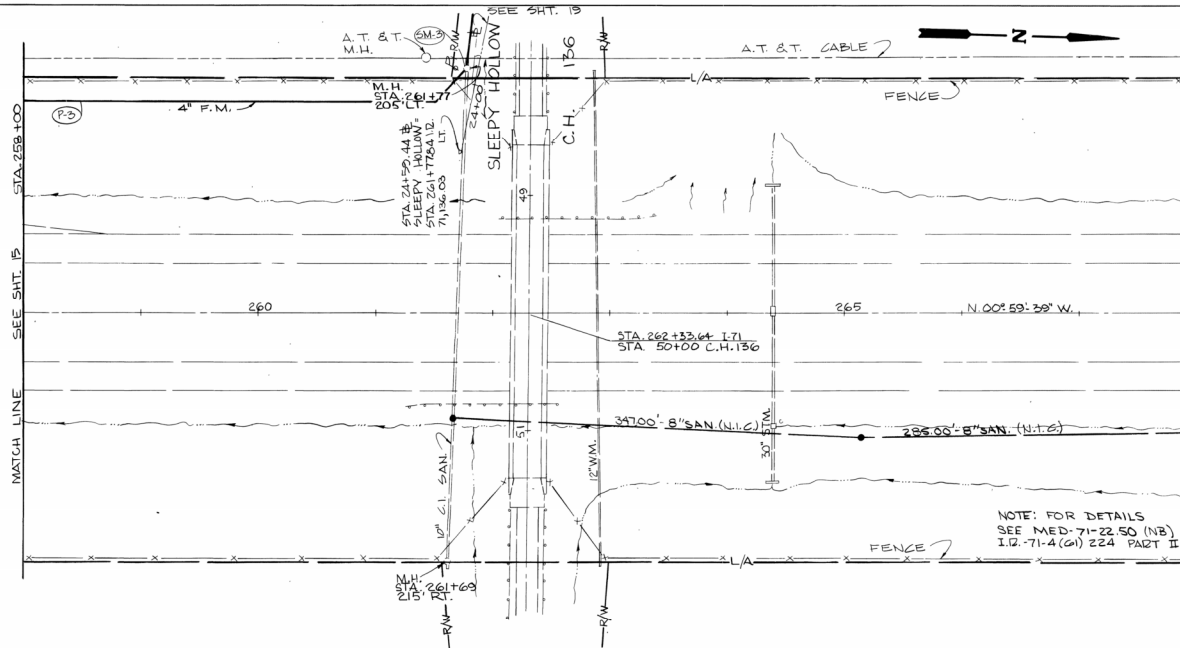


| FED. RD. DIVISION | STATE | PROJECT      |
|-------------------|-------|--------------|
| 5                 | OHIO  | MED-71-22.14 |

MEDINA COUNTY  
MED-71-22.14 (S.B.)  
IR-71-4(57)224 PART I

| MARK   | SIDE | STATION |        | 605                                               | 604                                   |
|--------|------|---------|--------|---------------------------------------------------|---------------------------------------|
|        |      | FROM    | TO     | 4\" DUCTILE CAST IRON PIPE 16\" PER PLAN LIN. FT. | RECONSTRUCT. MANHOLE AS PER PLAN EACH |
| P-3    | LT.  | 258+00  | 261+77 | 390                                               |                                       |
| SM-3   | LT.  | 261+77  |        |                                                   | 1                                     |
| TOTALS |      |         |        | 390                                               | 1                                     |

| BY      | DATE      |
|---------|-----------|
| CALC.   | MAD 8/24  |
| CHECKED | TRO 12/24 |

BENCH MARK:  
CHISELED "+" @ S.E. CORNER OF INLET  
@ S.B. TEST AREA @ STA. 41+00, 40' RT.  
ELEV. = 112.56


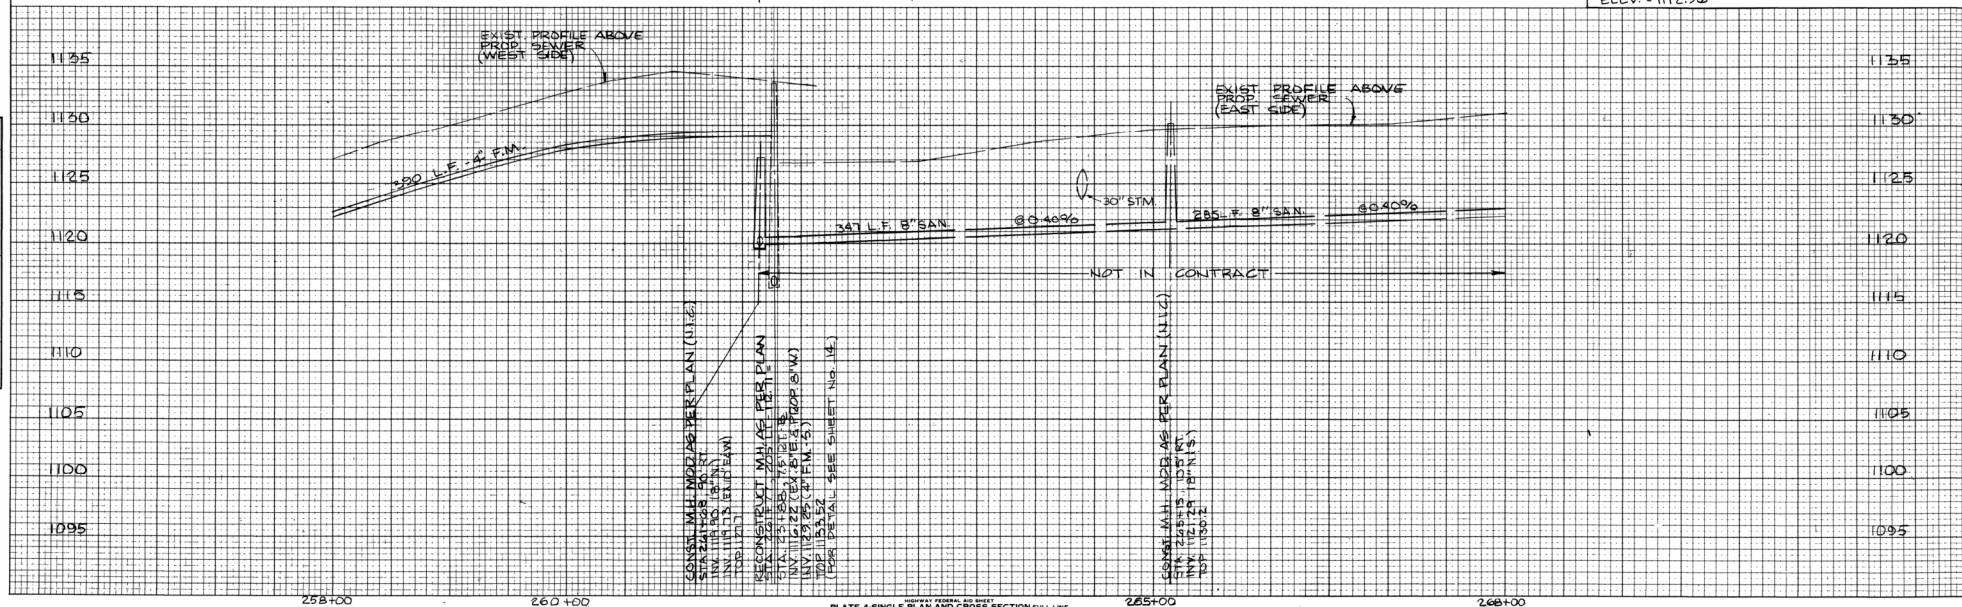


PLAN AND CROSS SECTION FULL LINE  
PRINTED IN U.S.A.

I-71 STA. 258+00 to STA. 268+00



|                 |               |      |
|-----------------|---------------|------|
| ORIGINAL SURVEY | BY            | DATE |
| SURVEYED        |               |      |
| PLOTTED         |               |      |
| TEMPLATE        |               |      |
| NOTE BOOK       |               |      |
| NO.             | AREAS CHECKED |      |
|                 |               |      |
|                 |               |      |

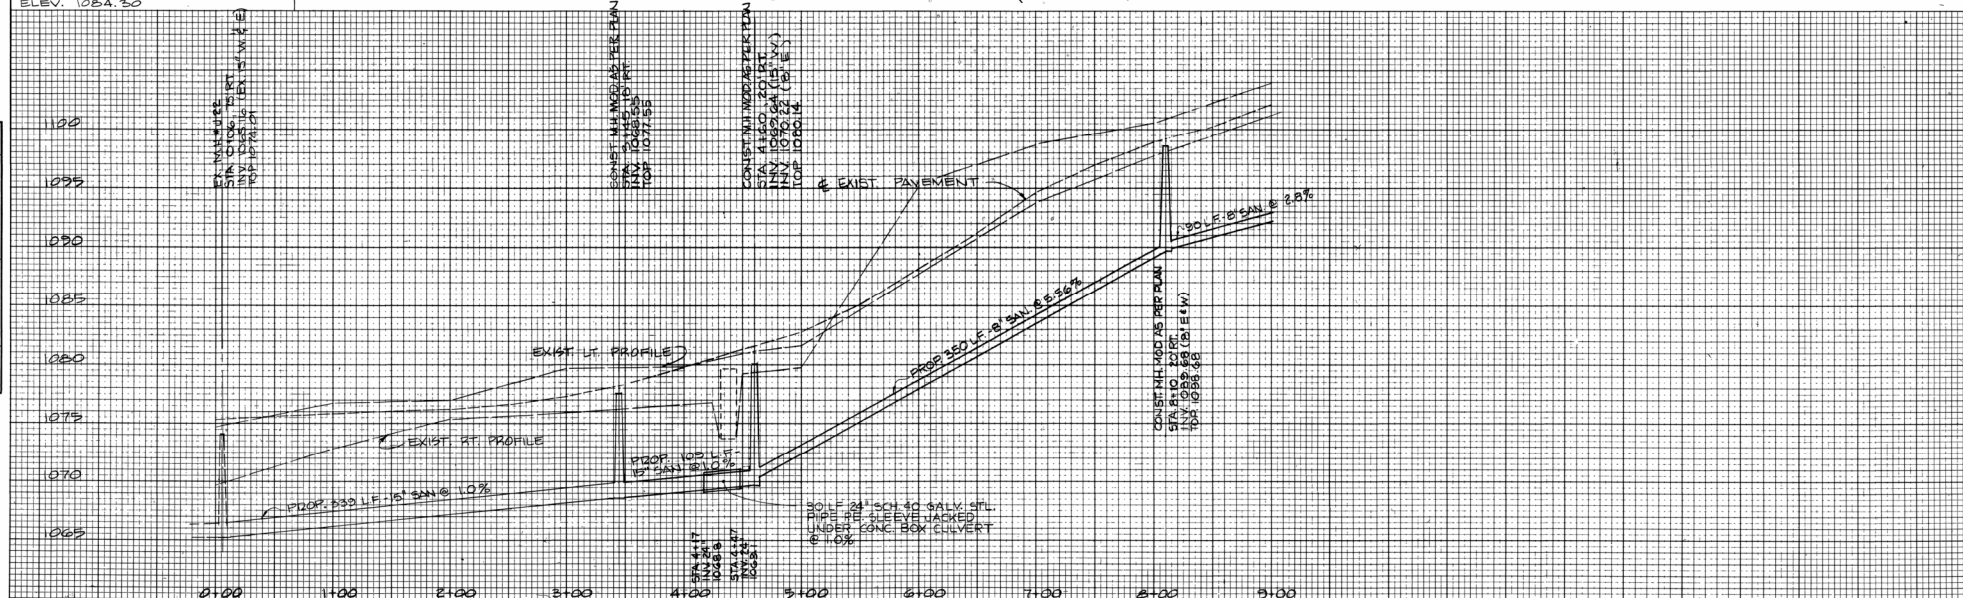 

HIGHWAY FEDERAL AID SHEET  
**PLATE 4-SINGLE PLAN AND CROSS SECTION-FULL LINE**  
 TELETYPE  
 PRINTED IN U.S.A.



PLAN & PROFILE STA. 0+00 TO STA. 3+00

|                   |       |              |  |
|-------------------|-------|--------------|--|
| FED. RD. DIVISION | STATE | PROJECT      |  |
| 5                 | OHIO  | MED-71-22.14 |  |

17  
47

MEDINA COUNTY  
MED-71-22.14 (S.B.)  
IR-71-4(57)224 PART I

| MARK SIDE |  | STATION |      | QUANTITIES                          |                                            |                                      |                                       |     |  |     |  |
|-----------|--|---------|------|-------------------------------------|--------------------------------------------|--------------------------------------|---------------------------------------|-----|--|-----|--|
|           |  |         |      | 603                                 |                                            | 603                                  |                                       | 603 |  | 604 |  |
|           |  |         |      | 8" SANITARY<br>SEWER AS<br>PER PLAN | 84" SCH. 40<br>SAULST. PIPE<br>AS PER PLAN | 15" SANITARY<br>SEWER AS<br>PER PLAN | MANHOLE<br>MODIFIED<br>AS PER<br>PLAN |     |  |     |  |
|           |  | FROM    | TO   | LIN. FT.                            | LIN. FT.                                   | LIN. FT.                             | EACH                                  |     |  |     |  |
| P-4       |  | 0+06    | 3+45 |                                     |                                            |                                      |                                       |     |  |     |  |
| U-3       |  | 3+45    |      |                                     |                                            | 359                                  |                                       |     |  |     |  |
| P-5       |  | 3+45    | 4+60 |                                     |                                            |                                      | 1                                     |     |  |     |  |
| U-3B      |  | 4+60    |      |                                     |                                            | 109                                  |                                       |     |  |     |  |
| P-6       |  | 4+60    | 8+10 | 350                                 |                                            |                                      |                                       |     |  |     |  |
| U-3B      |  | 8+10    |      |                                     |                                            |                                      | 1                                     |     |  |     |  |
| P-7       |  | 8+10    | 9+20 | 80                                  |                                            |                                      |                                       |     |  |     |  |
| P-8A      |  | 4+17    | 4+47 |                                     | 30                                         |                                      |                                       |     |  |     |  |
|           |  |         |      |                                     |                                            |                                      |                                       |     |  |     |  |
|           |  |         |      |                                     |                                            |                                      |                                       |     |  |     |  |
|           |  |         |      |                                     |                                            |                                      |                                       |     |  |     |  |
|           |  |         |      |                                     |                                            |                                      |                                       |     |  |     |  |
|           |  |         |      |                                     |                                            |                                      |                                       |     |  |     |  |
| TOTALS    |  |         |      | 440                                 | 30                                         | 448                                  | 3                                     |     |  |     |  |

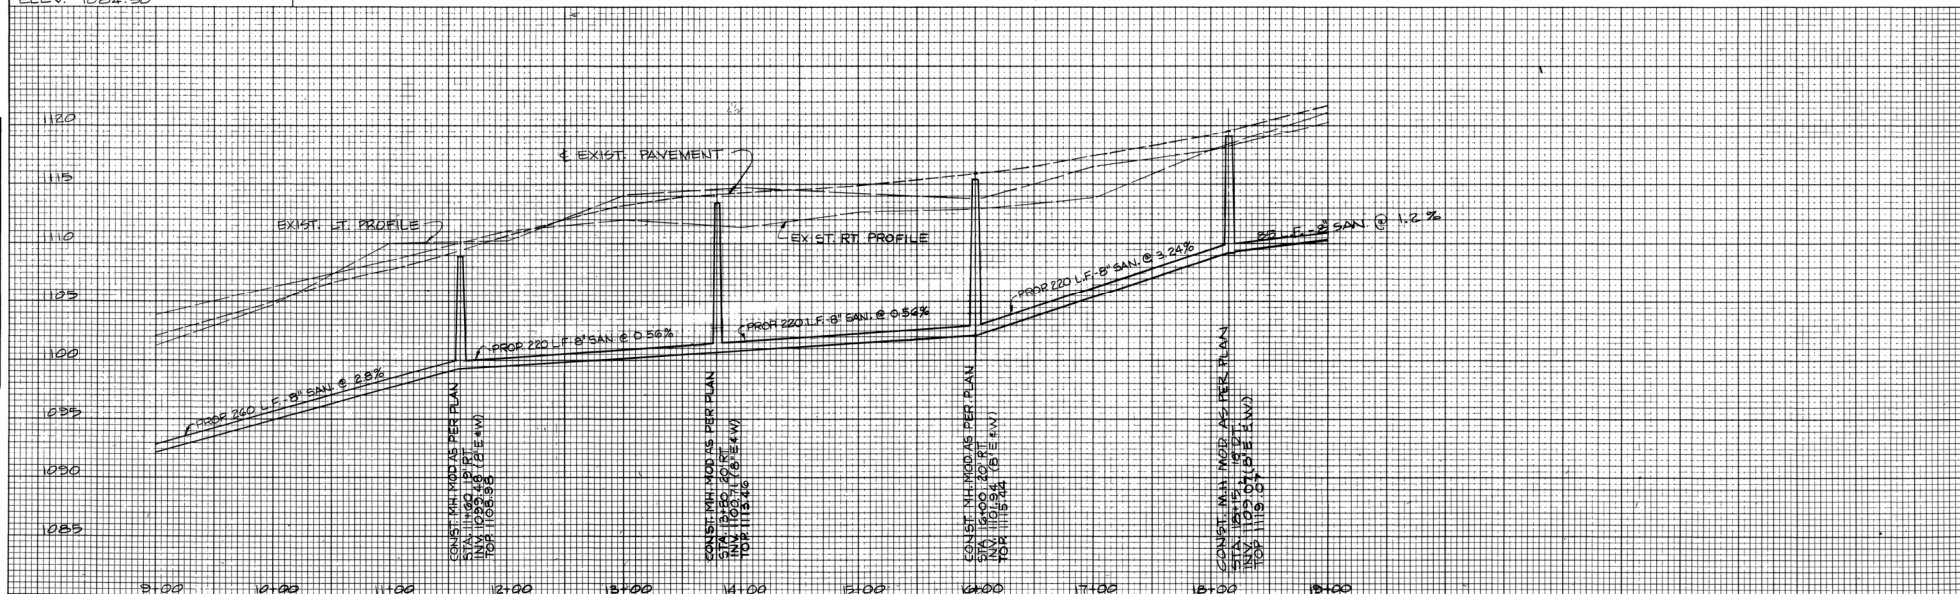 [illegible]


HIGHWAY FEDERAL AID SHEET  
 PLATE 4-SINGLE PLAN AND CROSS SECTION-FULL LINE  
 TELETYPE  
 PRINTED IN U.S.A.

PLAN & PROFILE STA. 9+00 TO STA. 19+00

|                   |       |              |
|-------------------|-------|--------------|
| FED. RD. DIVISION | STATE | PROJECT      |
| 5                 | OHIO  | MED-71-22.14 |

MEDINA COUNTY  
MED-71-22.14 (S.B.)  
IR-71-4(57)224 PART I

| MARK   | SIDE | STATION |       | G04                                           | G05                                  |
|--------|------|---------|-------|-----------------------------------------------|--------------------------------------|
|        |      | FROM    | TO    | MANHOLE<br>NOTIFIED<br>AS PER<br>PLAN<br>EACH | SEWANTARY<br>NOTIFIED<br>AS PER PLAN |
| P-8    |      | 9+00    | 11+60 |                                               | 220                                  |
| P-9    |      | 11+60   |       |                                               |                                      |
| P-9    |      | 11+60   | 13+80 |                                               | 220                                  |
| P-10   |      | 13+80   | 16+00 |                                               | 220                                  |
| P-30   |      | 16+00   |       |                                               |                                      |
| P-31   |      | 16+00   | 18+15 |                                               | 200                                  |
| P-40   |      | 18+15   |       |                                               |                                      |
| P-42   |      | 18+15   | 19+00 |                                               | 25                                   |
| TOTALS |      |         |       | 4                                             | 1005                                 |

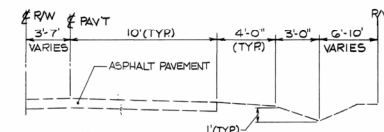

SLEEPY HOLLOW RD.  
TYPICAL SECTION



PLAN & PROFILE STA. 19+00 TO STA. 24+59.44

MED-71-22-14(5.B)

OHIO


20  
47FHWA  
REGION 5

## ROOM FINISH SCHEDULE


| RM. NO. | ROOM NAME         | FLOOR           | BASE        | WALLS         | CEILING       | FLGHT  | REMARKS                |
|---------|-------------------|-----------------|-------------|---------------|---------------|--------|------------------------|
| 101     | MOTORIST SERVICES | QUARRY TILE     | QUARRY TILE | GLAZED TILE   | CONC. PAINTED | 9 1/4" | 1. THIN SET 2. 5' COVE |
| 102     | WOMEN'S TOILET    | Do              | Do          | Do            | Do            | Do     | Do                     |
| 103     | W. HANDICAPPED T. | Do              | Do          | Do            | Do            | Do     | Do                     |
| 104     | MECHANICAL        | CONC. W/ H2O NR | Do          | UNGLAZED TILE | Do            | Do     | 1. PAINTED             |
| 105     | MAINTENANCE/STOR. | Do              | Do          | Do            | Do            | Do     | Do                     |
| 106     | MEN'S TOILET      | QUARRY TILE     | QUARRY TILE | GLAZED TILE   | Do            | Do     | 1. THIN SET 2. 5' COVE |
| 107     | M. HANDICAPPED T. | Do              | Do          | Do            | Do            | Do     | Do                     |
| 108     | MECHANICAL        | CONC. W/ H2O NR | NONE        | UNGLAZED TILE | Do            | Do     | 1. PAINTED             |

## DOOR SCHEDULE


| DOOR NO. | TYPE  | SIZE                       | HARDWR. | JAMB DET. | REMARKS                                          |
|----------|-------|----------------------------|---------|-----------|--------------------------------------------------|
| 01       | GA-02 | 3'-5" x 6'-11" x 1 3/4"    | A       | GE-06     | FURNISH W/ NOMINAL 4 1/2" HIGH CENTER CROSS RAIL |
| 02       | GA-02 | 3'-5" x 6'-11" x 1 3/4"    | A       | GE-06     | "SIT TO ABOVE"                                   |
| 03       | SD-16 | 3'-0" x 6'-11" x 1 3/4"    | B       | GA-08     | 1 1/2" B LABEL DOOR & FR. W/ V.P. SEE GO-16      |
| 04       | GA-03 | 2'-6" x 6'-11" x 1 3/4"    | C       | GA-08     |                                                  |
| 05       | GA-03 | 3'-0" x 6'-11" x 1 3/4"    | C       | GA-07     | 3 HOUR 1 1/2" LABEL DOOR & FR. SEE GC-05         |
| 06       | GA-04 | 8'-2" x 8'-1" x 2"         |         | GE-10     | 2" REGULAR CLEARANCE TRACK                       |
| 07       | SD-16 | 3'-0" x 6'-11" x 1 3/4"    | B       | GA-05     | 1 1/2" B LABEL DOOR & FR. W/ V.P. SEE GO-16      |
| 08       | GA-03 | 2'-6" x 6'-11" x 1 3/4"    | C       | GA-06     |                                                  |
| 09       | GA-03 | 3'-7 3/4" x 7'-2" x 1 3/4" | D       | SHT. GD   | 3 REQ'D W/ SPECIAL FRAME. SEE SHT. NO. GO        |

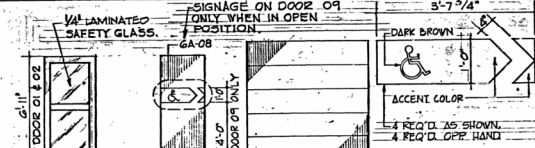

GA-02 GA-03 GA-04 INCORPORATED SIGNAGE DETAIL SCALE: 3/4" = 1'-0"

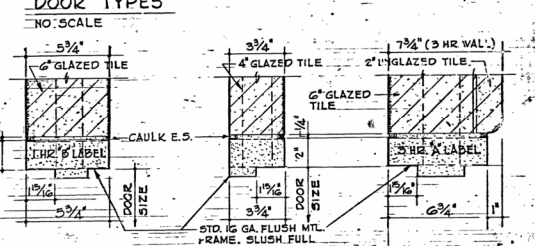


 GA-05 GA-06 GA-07 DOOR JAMB FRAMING DETAILS - HEADS SIMILAR SCALE 3" = 1'-0"





BUILDING USE AND OCCUPANCY INFORMATION  
FIRST FLOOR USE GROUP \_\_\_\_\_ B  
FIRE RATING HOURS \_\_\_\_\_ 2  
OCCUPANCY LOAD \_\_\_\_\_ 49  
FLOOR LIVE LOAD \_\_\_\_\_ 100 PS.F

| OHIO DEPARTMENT OF TRANSPORTATION<br>DIVISION OF HIGHWAYS                                                                                                                                               |                                                    |                        |
|---------------------------------------------------------------------------------------------------------------------------------------------------------------------------------------------------------|----------------------------------------------------|------------------------|
| REVISIONS<br>FOOT/REV. 1/8"<br>10-18-84<br>11-23-84                                                                                                                                                     | MOTORIST SERVICES BUILDING<br>AND<br>STORAGE UNITS | SHEET NO.<br><b>6A</b> |
| ARCHITECTS - WRIGH / KRITSCHGAU, ASSOCIATES, INC.<br>3600 TRABUE RD., COLUMBUS, OHIO<br>ENGINEERS - JOHN E. FOSTER & ASSOCIATES, COLUMBUS, OHIO<br>ENERGY TECHNOLOGIES - GATTEL & COLUMBUS LABORATORIES |                                                    | DATE                   |

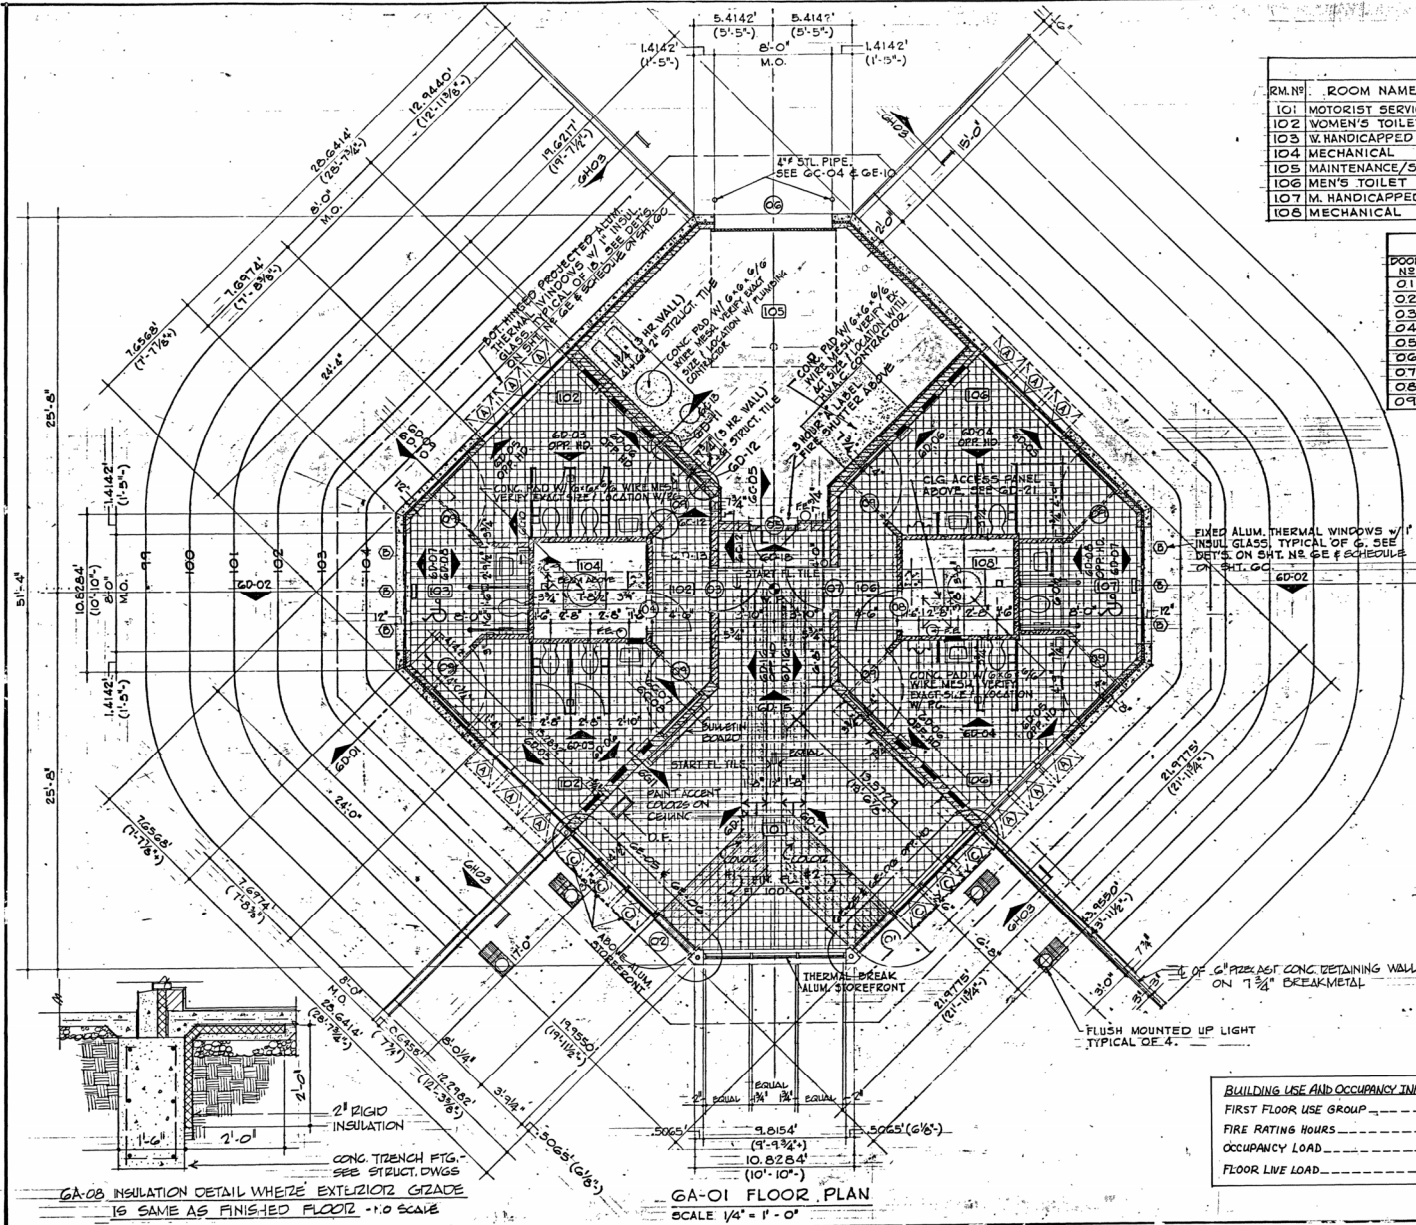






GA-08 INSULATION DETAIL WHERE EXTERIOR GRADE IS SAME AS FINISHED FLOOR - 1/2 SCALE

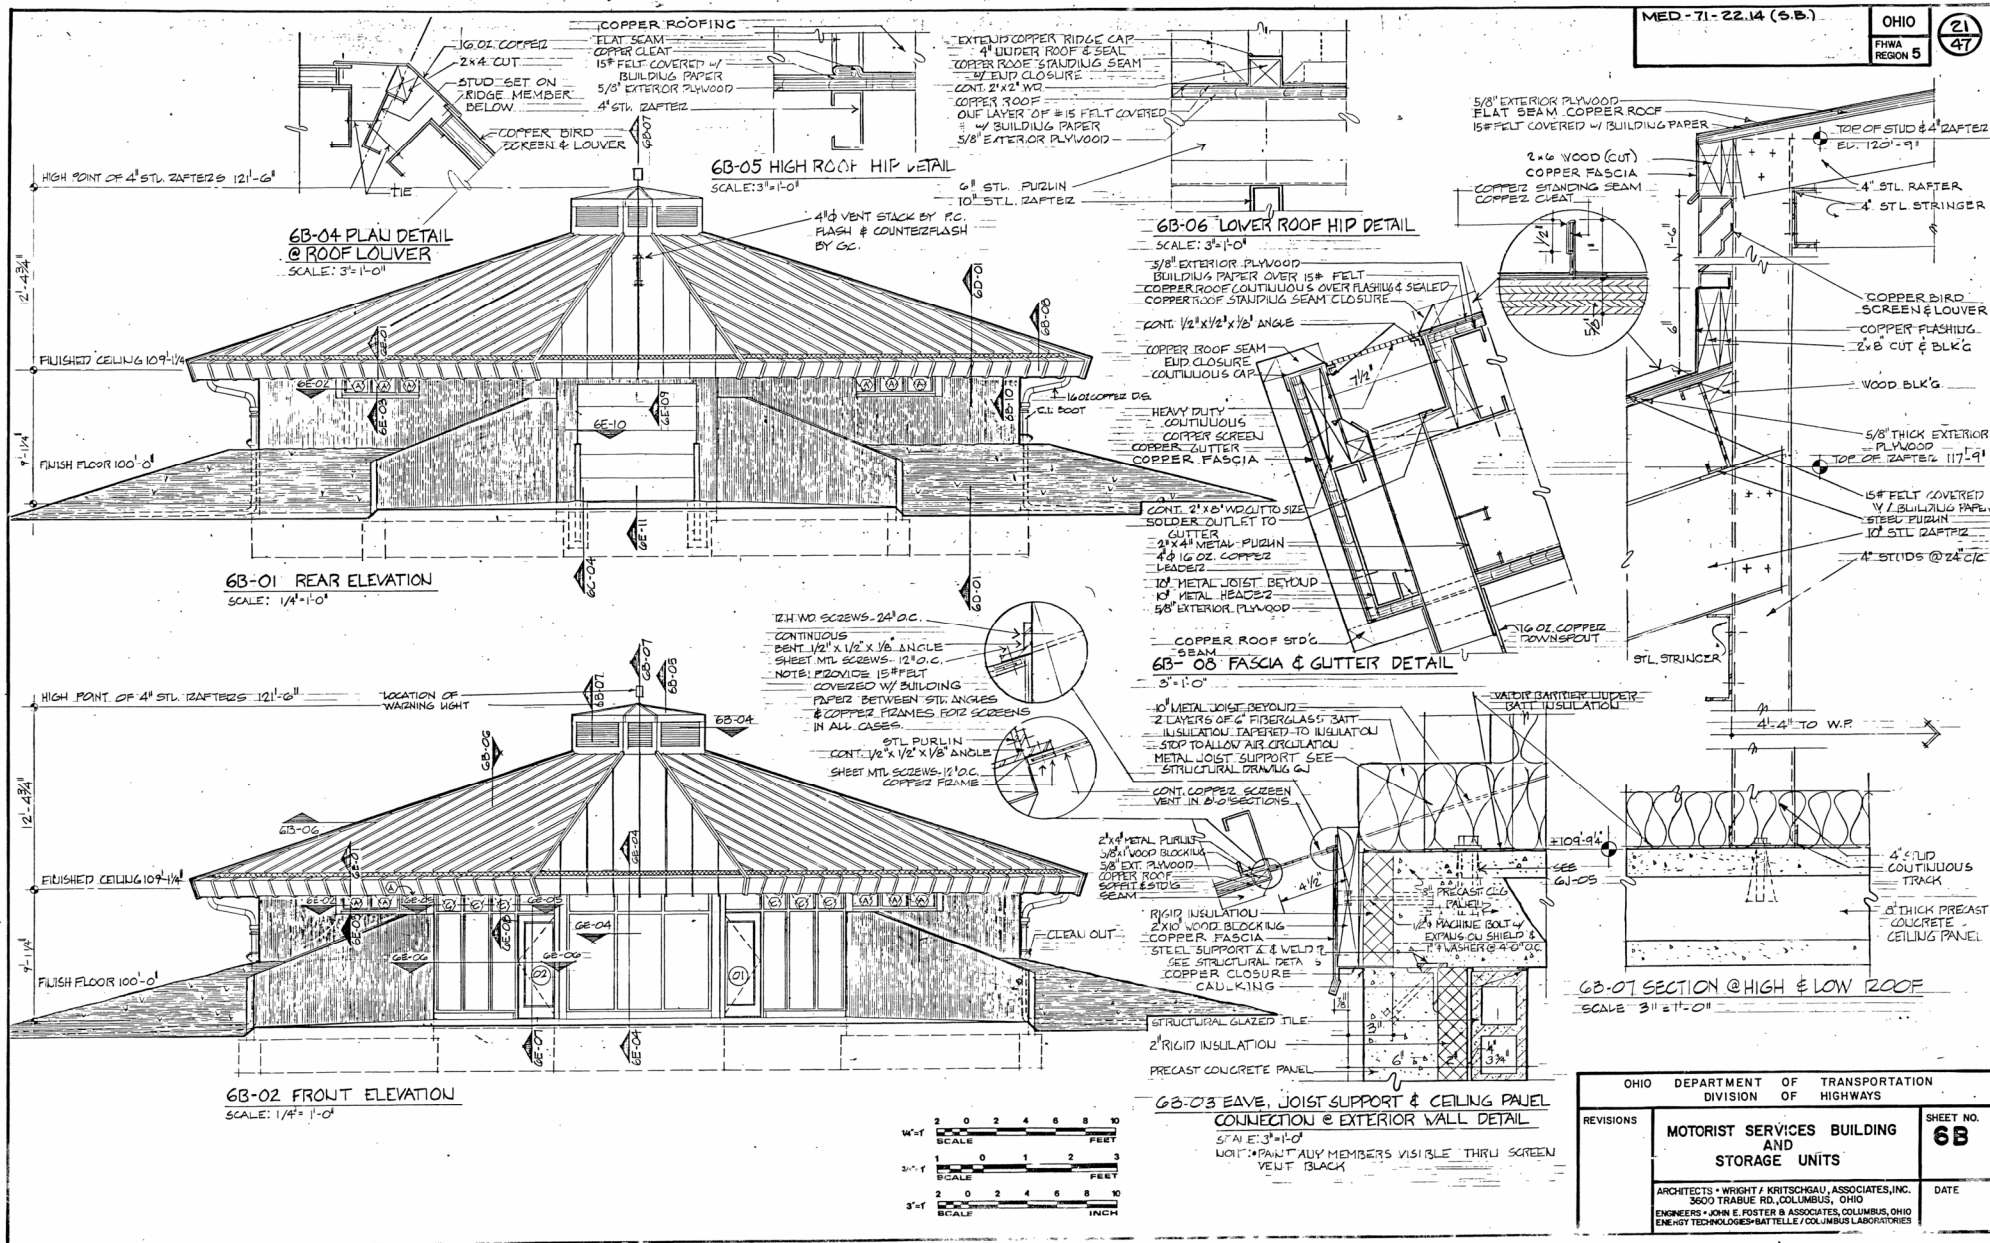

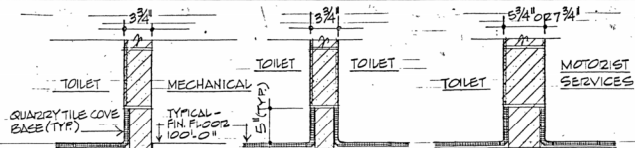GC-09  
BASE DETAILS  
NO SCALE




GC-10

GC-11

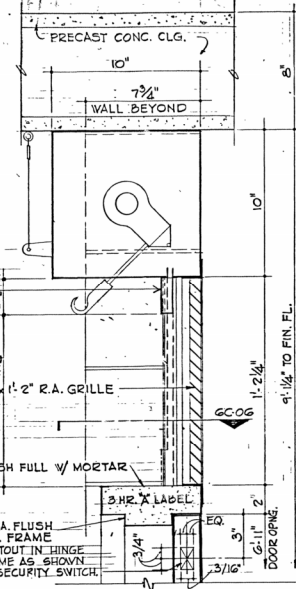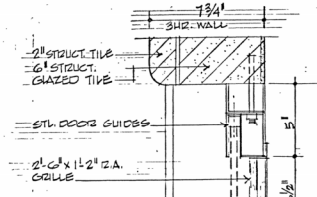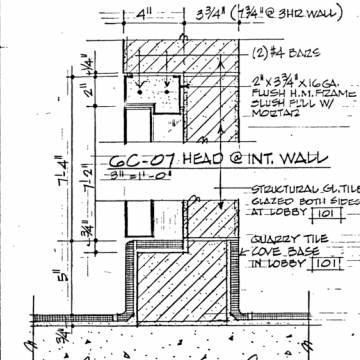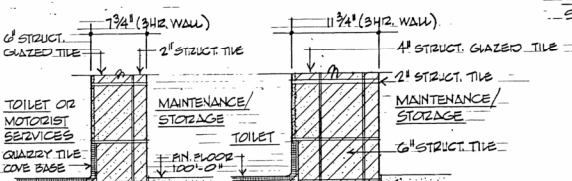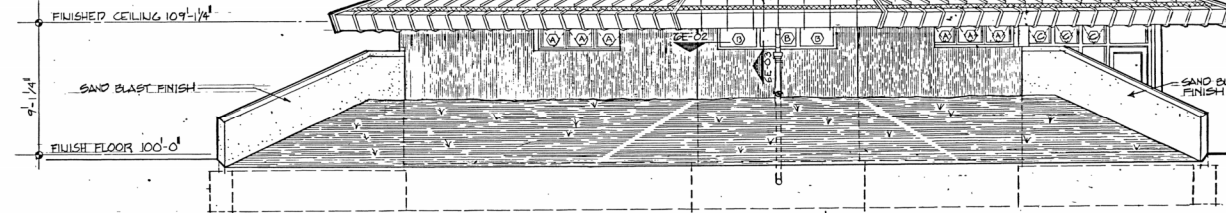4" VENT STACK BY P.C.  
FLASH & COUNTERFLASH  
BY GC.GC-05 HEAD & SILL  
ROLLING FIRE DOOR DETAILS AT ROOM 105  
SCALE: 3"=1'-0"GC-08 SILL @ INT. WALL  
DOOR NO. 09 FIRING DETAILS  
3" x 11'-0"  
SEE DETAILS GC-11 THRU GC-13GC-12  
BASE DETAILS  
NO SCALE

GC-13

HIGH POINT OF 4" STU. ZAPTERS 121'-6"

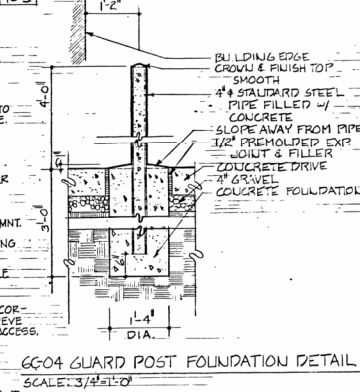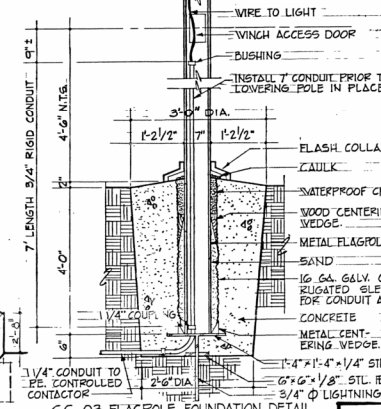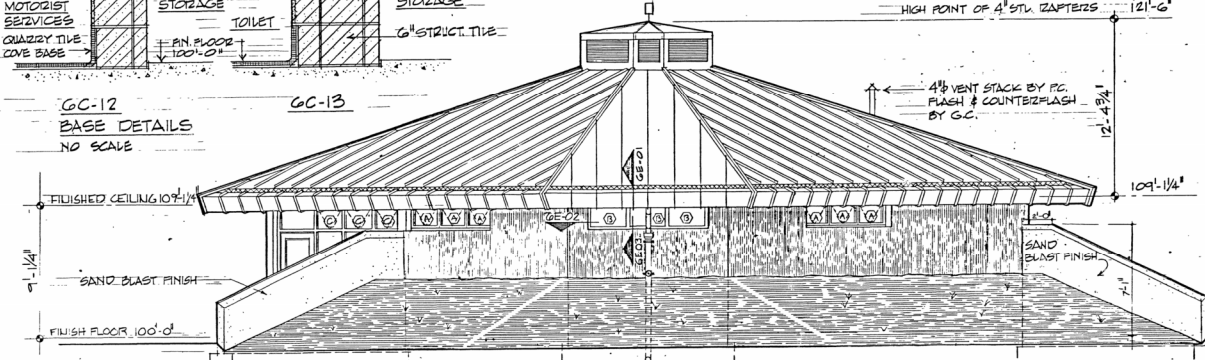4" VENT STACK BY P.C.  
FLASH & COUNTERFLASH  
BY GC.

| WINDOW SCHEDULE |               |             |          |             |           |                                          |
|-----------------|---------------|-------------|----------|-------------|-----------|------------------------------------------|
| WINDOW<br>NO.   | TYPE          | HEIGHT      | WIDTH    | DETAILS     | GLASS     | REMARKS                                  |
| (A)             | OPERABLE SASH | 11'-11 1/4" | SEE PLAN | GC-01, 2, 3 | 1" INSUL. | BOTTOM HINGED, PROJECTING W/ SCREEN      |
| (B)             | FIXED SASH    | 11'-11 1/4" | DO       | GC-01, 3, 3 | DO        | W/ 60-02 SCREEN                          |
| (C)             | OPERABLE SASH | 11'-9 1/2"  | DO       | GC-05, 3    | DO        | BOTTOM HINGED PROJECTING W/ 60-02 SCREEN |

OHIO DEPARTMENT OF TRANSPORTATION  
DIVISION OF HIGHWAYSREVISIONS  
7-17-84MOTORIST SERVICES BUILDING  
AND  
STORAGE UNITSSHEET NO.  
6CARCHITECTS: WRIGHT / KRITSCHAU, ASSOCIATES, INC.  
3600 TRABUE RD., COLUMBUS, OHIO  
ENGINEERS: JOHN E. FOSTER & ASSOCIATES, COLUMBUS, OHIO  
ENERGY TECHNOLOGIES-BATTELLE, COLUMBUS, OHIO

DATE




MED-71-22.14 (S.B.)

OHIO


REGION 5

23  
47

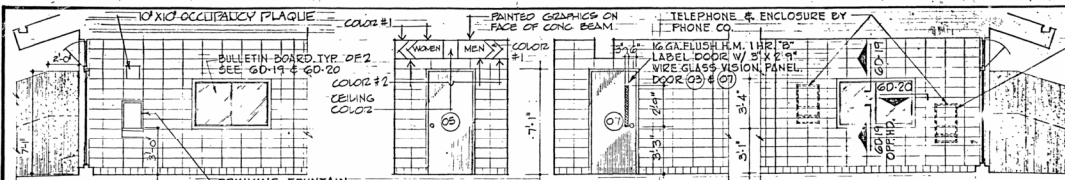


PHONE FOR HANDICAPPED TO BE  
INSTALLED TO COMPLY WITH  
ANSI A117.1, SECTION 4.31.

SEE GD-01

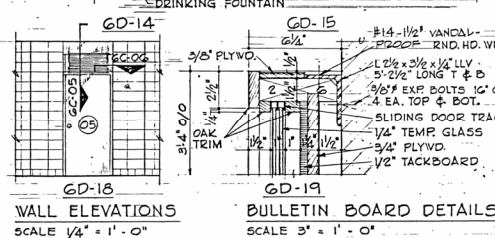


GD-14  
WALL ELEVATIONS  
SCALE 1/4" = 1'-0"

GD-15  
BULLETIN BOARD DETAILS  
SCALE 3" = 1'-0"

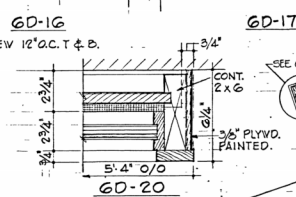


GD-18  
WALL ELEVATIONS  
SCALE 1/4" = 1'-0"

GD-19  
BULLETIN BOARD DETAILS  
SCALE 3" = 1'-0"

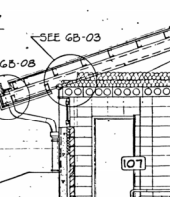


GD-21  
WALL ELEVATIONS  
SCALE 1/4" = 1'-0"


GD-22  
BULLETIN BOARD DETAILS  
SCALE 3" = 1'-0"

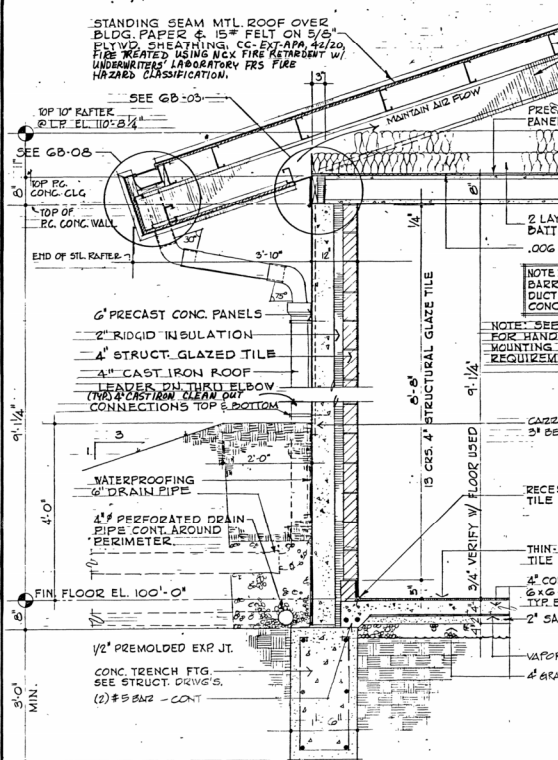


GD-01  
WALL ELEVATIONS  
SCALE 3/4" = 1'-0"

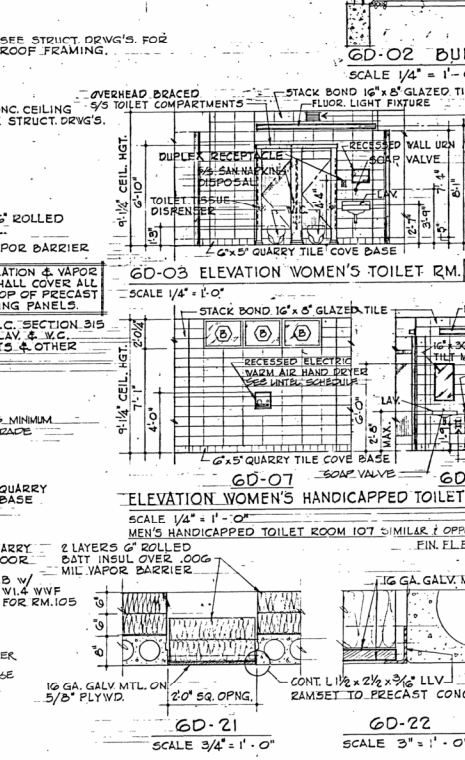

GD-04  
WALL ELEVATIONS  
SCALE 1/4" = 1'-0"

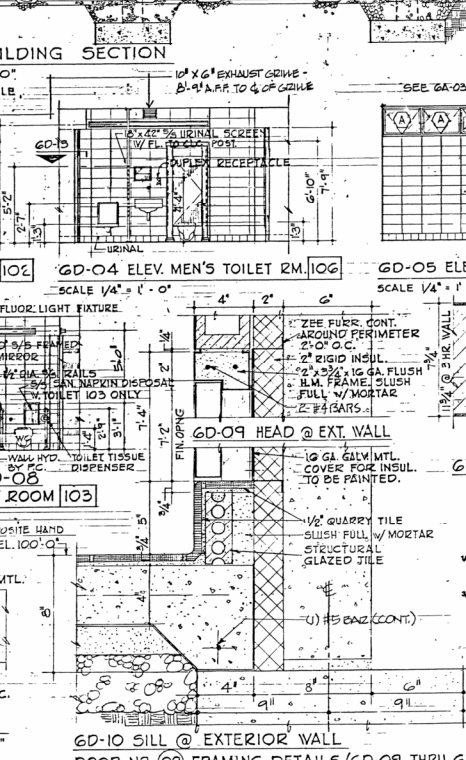

GD-07  
WALL ELEVATIONS  
SCALE 1/4" = 1'-0"

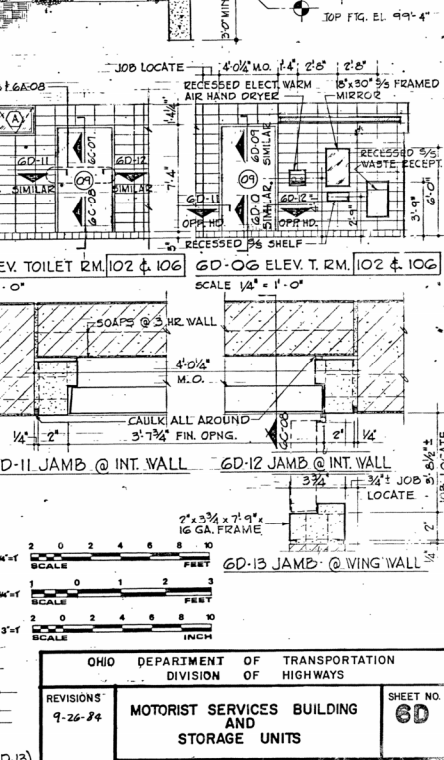

GD-10  
WALL ELEVATIONS  
SCALE 1/4" = 1'-0"

GD-01 TYPICAL WALL SECTION  
SCALE 3/4" = 1'-0"

CEILING ACCESS PANEL SECTION & DETAIL  
MECHANICAL ROOM 108

GD-10 SILL @ EXTERIOR WALL  
DOOR NO. 09 FRAMING DETAILS (GD-09 THRU GD-13)  
SCALE 3" = 1'-0"

GD-11 JAMB @ INT. WALL  
SCALE 1/4" = 1'-0"

GD-12 JAMB @ INT. WALL  
SCALE 1/4" = 1'-0"

GD-13 JAMB @ WING WALL  
SCALE 1/4" = 1'-0"

GD-14 JAMB @ WING WALL  
SCALE 1/4" = 1'-0"

GD-15 JAMB @ WING WALL  
SCALE 1/4" = 1'-0"

GD-16 JAMB @ WING WALL  
SCALE 1/4" = 1'-0"

GD-17 JAMB @ WING WALL  
SCALE 1/4" = 1'-0"

GD-18 JAMB @ WING WALL  
SCALE 1/4" = 1'-0"


GD-19 JAMB @ WING WALL  
SCALE 1/4" = 1'-0"

GD-20 JAMB @ WING WALL  
SCALE 1/4" = 1'-0"

GD-21 JAMB @ WING WALL  
SCALE 1/4" = 1'-0"

GD-22 JAMB @ WING WALL  
SCALE 1/4" = 1'-0"


| OHIO DEPARTMENT OF TRANSPORTATION<br>DIVISION OF HIGHWAYS                                                                                                                                               |                                                    |                 |
|---------------------------------------------------------------------------------------------------------------------------------------------------------------------------------------------------------|----------------------------------------------------|-----------------|
| REVISIONS<br>9-26-84                                                                                                                                                                                    | MOTORIST SERVICES BUILDING<br>AND<br>STORAGE UNITS | SHEET NO.<br>60 |
| ARCHITECTS: WRIGHT / KRITSCHGAU, ASSOCIATES, INC.<br>3600 TRABUE RD., COLUMBUS, OHIO<br>ENGINEERS: JOHN E. POSTER & ASSOCIATES, COLUMBUS, OHIO<br>ENERGY TECHNOLOGIES: BATTIOLI / COLUMBUS LABORATORIES |                                                    |                 |
|                                                                                                                                                                                                         |                                                    | DATE            |

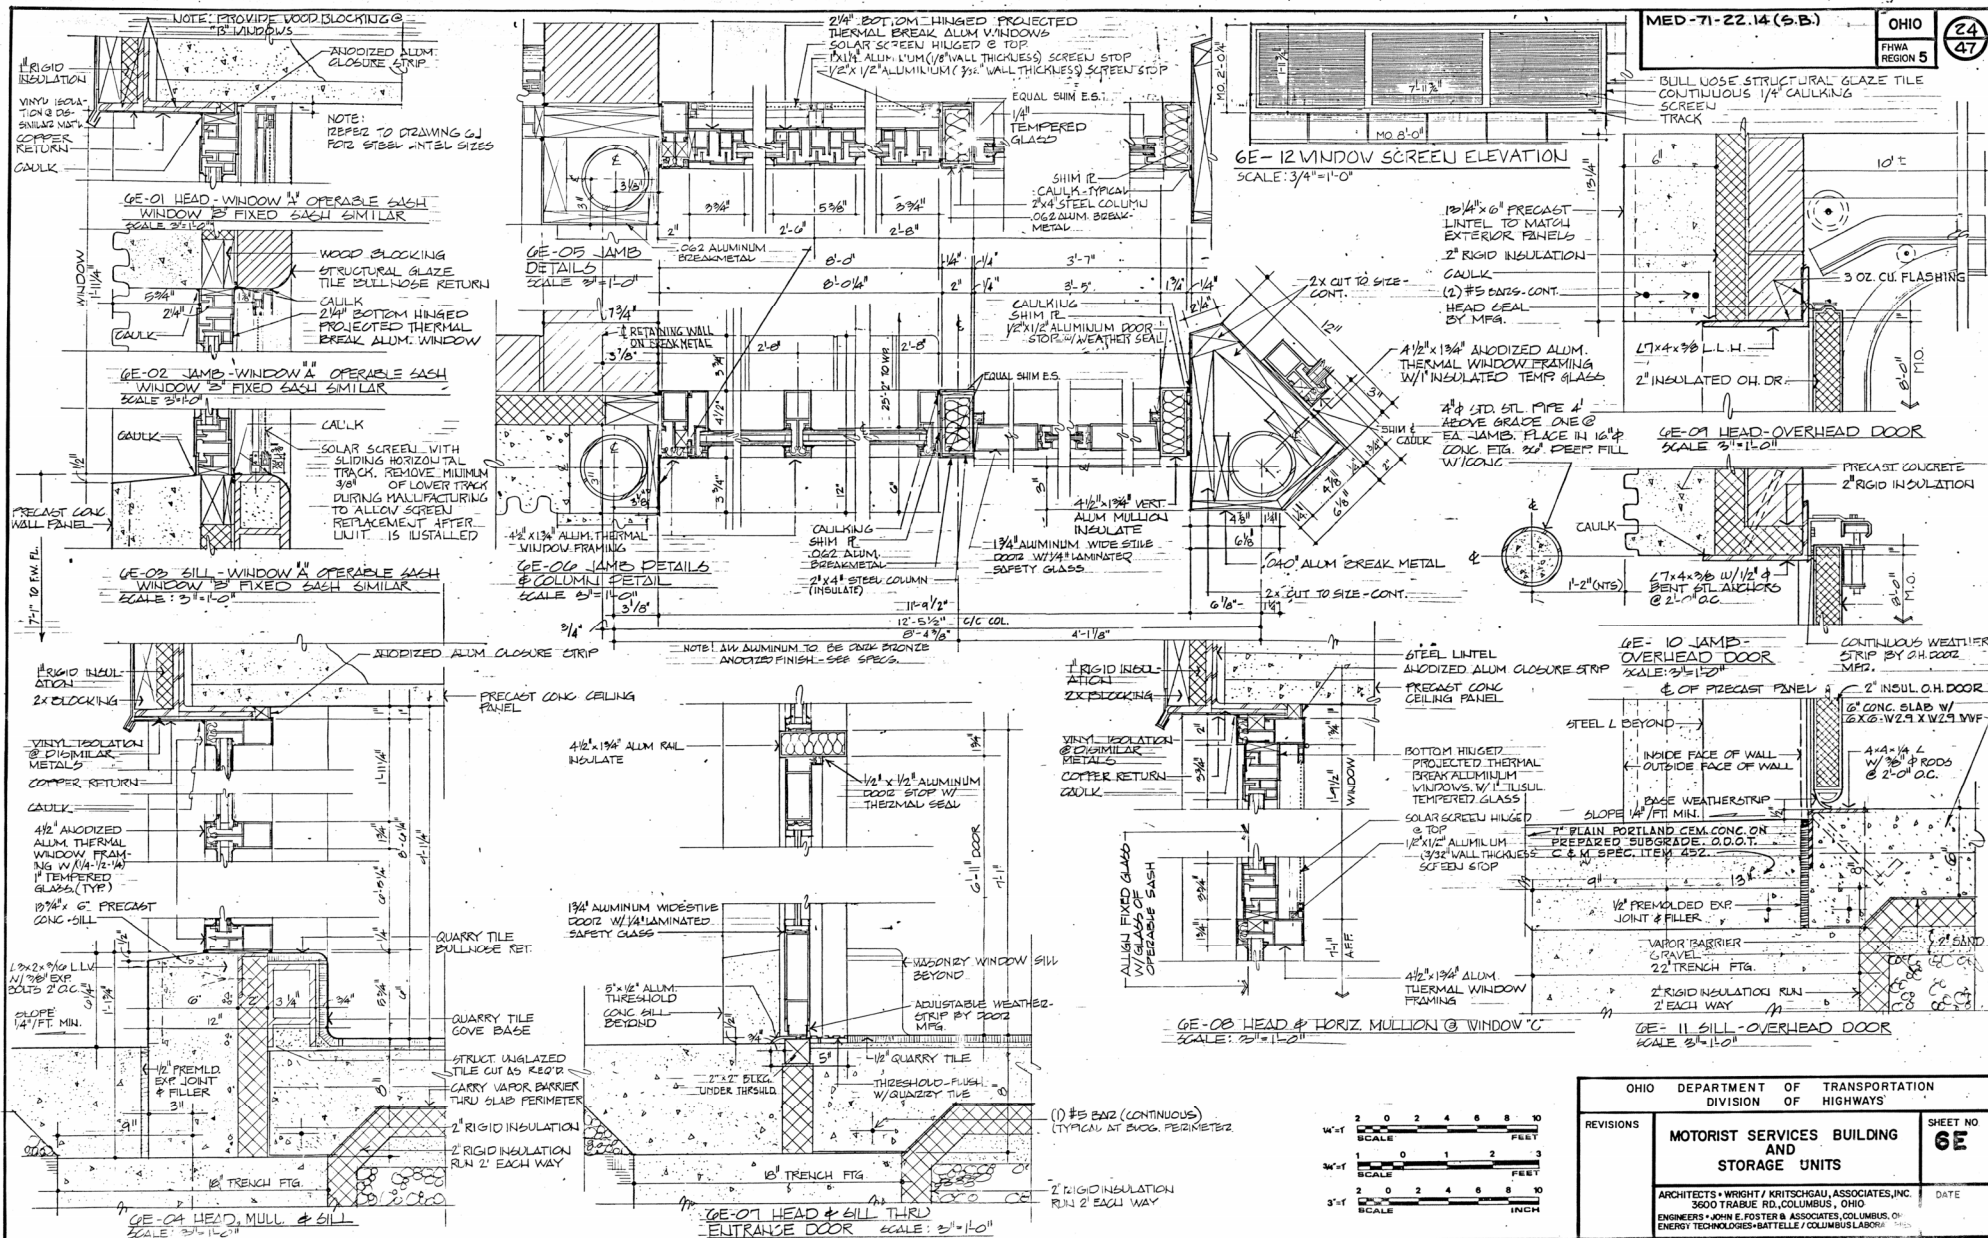





# GENERAL NOTES

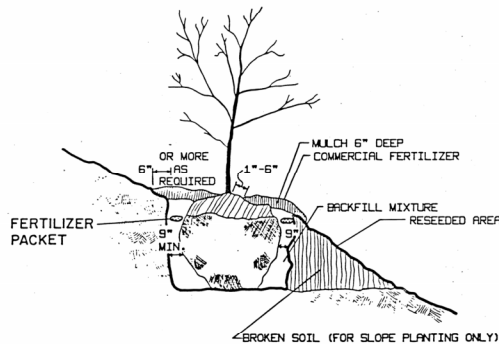

THE TOP OF THE ROOT BALL SHALL BE 1 INCH ABOVE THE NORMAL GROUND LINE IN AVERAGE SOILS, 3 INCHES IN HEAVY CLAY SOILS AND 6 INCHES WHERE IMPERMEABILITY IS ENCOUNTERED.

ON SLOPES WHERE HEAVY CLAY AND IMPERMEABLE SOILS ARE PRESENT THE DOWN HILL SIDE OF THE POCKET HOLE SHALL BE BROKEN OR LOOSENED AND RETURNED TO ITS NATURAL GRADE TO PROVIDE DRAINAGE FOR THE HOLE.

## PLANTING HOLE AND BED PREPARATION

AFTER THE LAYOUT IS APPROVED BY THE ENGINEER, SHALES SHALL BE CULTIVATED TO A MINIMUM DEPTH OF SIX (6) INCHES BY A PLOW, HARROW OR DISC, OR OTHER METHOD APPROVED BY THE ENGINEER. THE CULTIVATION SHALL TAKE PLACE AS FAR IN ADVANCE OF THE PLANTING OPERATION AS POSSIBLE. WHERE SHALES ARE SHOWN, INDIVIDUAL HOLES SHALL BE DUG ON CENTERS AS SHOWN ON THE PLANS. THESE HOLES SHALL ALLOW FOR A MINIMUM OF NINE (9) INCHES OF BACKFILL MIXTURE AROUND THE SIDES OF THE BALLS. THE BOTTOM OF THE HOLE SHALL BE NO DEEPER THAN THE BALL TO BE PLANTED. THE MATERIAL REMOVED FROM THE HOLES SHALL BE TAKEN FROM THE PROJECT IF IT IS FOUND TO BE UNACCEPTABLE FOR USE AS BACKFILL AS DETERMINED BY THE ENGINEER. THE PLANT SHALL THEN BE SET AND THE HOLE FILLED WITH BACKFILL MIXTURE, AND THE PLANTING OPERATION PERFORMED AS SPECIFIED IN ITEMS 662.17 AND 662.18. ALL EXCESS DIRT SHALL BE REMOVED FROM THE SITE.

EXISTING TREES AND SHRUBS SHALL TAKE PRIORITY OVER PROPOSED PLANTINGS. THE LOCATIONS OF THE PROPOSED TREES AND SHRUBS ARE APPROXIMATE AND MAY BE REARRANGED AT THE DIRECTION OF THE ENGINEER WHEN OBSTRUCTIONS ARE ENCOUNTERED.

IF AN AUGER IS USED IN DIGGING POCKET HOLES AND POLISHED (SHINY) SIDES OCCUR IN CLAY OR HEAVY SOILS, THE USE OF SUCH AN AUGER SHALL BE DISCONTINUED AND THE HOLES SHALL BE DUG WITH A BACKHOE OR ANOTHER APPROVED METHOD.

BACKFILL NO. 1 - THE BACKFILL MIXTURE USED TO FILL POCKET HOLES IN LIGHT AND MEDIUM SOILS (SAND & AVERAGE) SHALL CONSIST BY VOLUME OF: 2 PARTS \*SOIL CONDITIONER, 2 PARTS COMPRESSED SPAGNUM PEAT OR 3 PARTS SEDGE PEAT, AND 2 PARTS APPROVED TOPSOIL.

BACKFILL NO. 2 - THE BACKFILL MIXTURE USED TO FILL POCKET HOLES IN HEAVY SOILS (CLAY & SHALE) SHALL CONSIST BY VOLUME OF: 1 PART \*SOIL CONDITIONER, 1 PART COMPRESSED SPAGNUM PEAT OR 2 PARTS SEDGE PEAT, AND 2 PARTS APPROVED TOPSOIL.

INCORPORATE THOROUGHLY INTO THE BACKFILL MIXTURES 5 LBS. OF COMMERCIAL FERTILIZER (10-20-20) PER CUBIC YARD. THE ENGINEER, AFTER CONSULTATION WITH THE DIST. HORT. OR L.A. SHALL DETERMINE THE LOCATIONS WHERE THE BACKFILL MIXTURES SHALL BE USED.

## SCHEDULING

ALL DIGGING AND PLANTING OF DECIDUOUS PLANTS SHALL BE DONE AFTER OCTOBER 1, AND BEFORE JUNE 1. EVERGREENS SHALL BE DUG AND PLANTED AFTER MARCH 15, AND BEFORE JUNE 1.

ITEMS 662 & 663

ALL TREES AND SHRUBS SHALL BE SPECIMEN (NO.1 GRADE) PLANTS WITH GROWTH AND BRANCHING HABIT TYPICAL OF THE SPECIES SPECIFIED. NO PARK GRADE (NO. 2 OR 3 GRADE) PLANTS WILL BE ACCEPTED.

## FERTILIZER

FOUR OUNCE (8 YEAR) COMMERCIAL FERTILIZER PACKETS USED IN PLANTING OPERATION SHALL BE DELIVERED DRY IN ORIGINAL, UNOPENED CONTAINERS. FERTILIZER ANALYSIS SHALL BE 16% NITROGEN, 8% PHOSPHORIC ACID AND 16% POTASH. FERTILIZER SHALL BE OF A SLOW RELEASE TYPE IN A POLYETHYLENE PERFORATED PACKET WITH MICROPORE HOLES.

THE PACKETS SHALL BE PLACED 6 TO 8 INCHES DEEP AND EVENLY SPACED AROUND THE PERIMETER OF THE PLANTING HOLE, ADJACENT TO THE BALL OR ROOT MASS BUT NOT IN DIRECT CONTACT WITH THE ROOTS. THE PACKETS SHALL NOT BE CUT, RIPPED OR DAMAGED.

EACH SHRUB OR TREE SHALL BE FERTILIZED ACCORDING TO THE FOLLOWING SCHEDULE:

|        |                  |           |
|--------|------------------|-----------|
| VINES  | 1'-2'            | 1 PACKET  |
| SHRUBS | 1'-3'            | 2 PACKETS |
| SHRUBS | 3'-4'            | 3 PACKETS |
| TREES  | 5'-6'            | 3 PACKETS |
| TREES  | 6'-8'            | 4 PACKETS |
| TREES  | 1 1/2" - 2" CAL. | 2 PACKETS |
| TREES  | 2" - 2 1/2" CAL. | 3 PACKETS |
| TREES  | 2 1/2" - 3" CAL. | 4 PACKETS |
| TREES  | 3" - 3 1/2" CAL. | 5 PACKETS |

IF IT BECOMES NECESSARY TO REMOVE AND REPLACE MISSING, DEAD OR UNHEALTHY PLANTS, ALL OLD (USED) PACKETS SHALL BE REPLACED WITH NEW PACKETS.

THE FOUR OUNCE 16-8-16 FERTILIZER PACKETS SHALL BE DESIGNATED BY THE MANUFACTURER TO BE EFFECTIVE FOR EIGHT YEARS. PACKETS SUCH AS "KEESTY GROW", "THE UNIQUE FEEDER" OR AN APPROVED EQUAL SHALL BE USED.

## ITEM 661.21 WATERING

WATER SHALL BE FURNISHED BY THE CONTRACTOR AND ALL PLANT MATERIAL SHALL BE WATERED THOROUGHLY AT THE TIME OF PLANTING REGARDLESS OF AMPLE MOISTURE CONTENT OF THE SURROUNDING SOIL. SUSPENSION OF WATERING OPERATIONS BECAUSE OF RAINFALL WILL BE DETERMINED BY THE ENGINEER IN CONSULTATION WITH THE DISTRICT HORTICULTURIST OR L.A. AN AVERAGE OF ONE INCH OF RAINFALL PER WEEK SHALL BE CONSIDERED ADEQUATE. DETERMINATION OF RAINFALL SHALL BE BASED UPON THE USE OF A RAIN GAUGE APPROVED BY THE PROJECT ENGINEER & PROVIDED BY THE CONTRACTOR.

## MULCH

MULCH SHALL BE AS PER ITEM 661.04 WITH THE FOLLOWING EXCEPTIONS: WOOD SHAVINGS OR PEAT MOSS OR CORN COBS SHALL NOT BE USED AS A TOP MULCH. WOOD CHIPS SHALL BE AGED (STOCKPILED) AT LEAST 6 MONTHS PRIOR TO PLACEMENT AROUND PLANTS. MULCH SHALL BE SIX INCHES LOOSE MEASUREMENT. AFTER MULCHING, COMMERCIAL FERTILIZER (12-12-12) SHALL BE APPLIED AS SPECIFIED IN ITEM 662.18.

## PRUNING

ALL PLANTS SHALL BE PRUNED WITHIN SEVEN DAYS AFTER PLANTING. THE PRUNING SHALL BE DONE ACCORDING TO SELECTED TYPICAL PLANTS OF EACH SPECIES PRUNED AND USED AS A SAMPLE AS DIRECTED BY THE ENGINEER.

ANY CANDLE GROWTH ON NEEDLE EVERGREENS WHICH EXCEED 3 INCHES AT PLANTING TIME SHALL BE CUT BACK TO THAT LENGTH IMMEDIATELY.

## STORAGE AREAS

THE CONTRACTOR MAY STORE MATERIALS AND EQUIPMENT 30 FEET FROM PAVEMENT, BEHIND GUARDRAIL AND WITHIN OR ADJACENT TO THE PROJECT LIMITS BY OBTAINING OFFICIAL PERMISSION OF THE ENGINEER. NO FEEDSTOCK OF VEHICULAR TRAFFIC MAY BE IMPEDED NOR HAZARDOUS CONDITION CREATED AS A RESULT OF SUCH STORAGE.

THE STORAGE OF ALL DUG PLANTS SHALL CONFORM TO 661.14 WHETHER WITHIN THE PROJECT LIMITS, ADJACENT THERETO, OR AT SOME OTHER LOCATION. THESE AREAS SHALL BE DESIGNATED PRIOR TO ACTUAL PLANT STORAGE AND SHALL BE OPEN TO INSPECTION UPON REQUEST OF THE ENGINEER.

## STAKING MATERIALS

ALL TREES SHALL BE STAKED AS SHOWN IN THE STANDARD DRAWING LA-2. STAKING OF SMALL ORNAMENTAL TREES SHALL BE SIMILAR TO THAT OF EVERGREENS. ALL DECIDUOUS TREE TRUNKS ARE TO BE TREATED WITH LINDANE SPRAY BEFORE WRAPPING.

CALC BY \_\_\_\_\_ DATE \_\_\_\_\_  
CHKD BY \_\_\_\_\_ DATE \_\_\_\_\_

## TOPSOIL TESTING

TOPSOIL FAILING CURRENT TEST STANDARDS MAY BE ALTERED, UPON APPROVAL OF THE ENGINEER, BY ADDING APPROVED CONDITIONERS TO CORRECT THE DEFICIENCIES. TOPSOIL SHALL BE FREE OF JOHNSON GRASS AND CONFORM TO ITEM 663 AS DETERMINED BY THE ENGINEER.

## PLANTING PERIOD OF ESTABLISHMENT

BEFORE FINAL INSPECTION, ALL PLANTINGS SHALL BE IN PLACE AND UNDER THE CARE OF THE CONTRACTOR FOR A PERIOD OF ESTABLISHMENT. THIS PERIOD SHALL BEGIN IMMEDIATELY UPON COMPLETION OF THE PLANTING OPERATION FOR ANY PLANT OR SPECIES GROUP AND CONTINUE UNTIL OCTOBER 1. IN NO CASE SHALL IT BE LESS THAN ONE GROWING SEASON, JUNE 1 TO OCTOBER 1.

DURING THIS PERIOD OF ESTABLISHMENT, IT SHALL BE THE CONTRACTOR'S RESPONSIBILITY TO FOLLOW SUCH HORTICULTURAL PRACTICES AS REQUIRED TO ASSURE THE VIGOR AND GROWTH OF THE TRANSPLANTED MATERIAL. THIS CARE SHALL INCLUDE WATERING, REMULCHING, RESTRAINING, GUYING AND CULTIVATING. THERE SHALL BE A MINIMUM OF TWO WEEDING AND MOWING (BED EDGES, AROUND TREES AND GUY STAKES) PROGRAMS OF SUCH INTENSITY AS TO COMPLETELY RID THE PLANTED AND MULCHED AREAS OF WEEDS AND GRASSES. THE FIRST PROGRAM SHALL BEGIN ON OR ABOUT JUNE 15 AND THE OTHER APPROXIMATELY 8 WEEKS LATER.

EACH PLANT SHALL HAVE SUFFICIENT WATER TO KEEP IT IN A HEALTHY, GROWING CONDITION. IF LOCAL WEATHER CONDITIONS WARRANT, THE ENGINEER MAY REQUIRE WEEKLY WATERING. WHEN WATERING IS REQUIRED, A SCHEDULE FOR WATERING EACH PLANT SHALL BE SUPPLIED TO AND APPROVED BY THE ENGINEER. THE WATER SHALL BE APPLIED IN SUCH A MANNER AS TO SATURATE THE ROOT AND MULCHED AREA OF EACH PLANT WITHOUT CAUSING RUNOFF (SEE WATERING TABLE). IN CASE OF FALL PLANTINGS, THESE WATERINGS SHALL CONTINUE UNTIL SOIL FREEZE-UP AND RECOMMENCE AFTER THE SPRING THAW UNLESS OTHERWISE DIRECTED.

ON OR ABOUT SEPTEMBER 15, THE ENGINEER SHALL INSPECT THE PLANTING AND SUPPLY THE CONTRACTOR WITH A LISTING OF THOSE PLANTS HAVING DIED, DIED BACK BEYOND NORMAL PRUNING LINES OR ARE MISSING FROM THE PLANTING. THE CONTRACTOR SHALL MAKE THE REPLANTING AS REQUIRED AND IN ACCORDANCE WITH THE SPECIFICATIONS FOR THE ORIGINAL MATERIAL. THESE REPLACEMENTS ARE NOT SUBJECT TO THE PERIOD OF ESTABLISHMENT. HOWEVER, PLANTS PLANTED INITIALLY IN THE FALL WHICH HAVE DIED BEFORE THE SPRING PLANTING SEASON SHALL BE REPLACED IMMEDIATELY AND ARE SUBJECT TO THE ESTABLISHMENT PERIOD.

AFTER REPLACEMENTS HAVE BEEN PLANTED, THE FINAL INSPECTION SHALL BE MADE AND THE ACTUAL COUNT OF LIVE PLANTS OF EACH VARIETY AND SPECIES LISTED FOR PAYMENT.

## WATERING TABLE

|                            |                      |
|----------------------------|----------------------|
| VINES 1'-2' SIZE           | 2 GALLON PER PLANT   |
| SHRUBS 1'-3' SIZE          | 4 GALLONS PER PLANT  |
| SHRUBS 4'-5' SIZE          | 7 GALLONS PER PLANT  |
| TREES 5'-6' SIZE           | 10 GALLONS PER PLANT |
| TREES 1-1/4" - 1-1/2" CAL. | 15 GALLONS PER PLANT |
| TREES 1-1/2" - 2" CAL.     | 20 GALLONS PER PLANT |
| TREES 2"-3" CAL.           | 25 GALLONS PER PLANT |
| TREES 3"-4" CAL.           | 30 GALLONS PER PLANT |

THE METHOD OF MEASUREMENT FOR SUMMER WATERING SHALL BE BY APPROVED METERING FROM TANKS OR BY INDIVIDUALLY MEASURED CONTAINERS TO EACH PLANT TO BE WATERED. PAYMENT FOR PLANTING PERIOD OF ESTABLISHMENT SHALL BE INCLUDED IN THE UNIT PRICE BID FOR ITEMS 661, 662 AND 663.

## \*SOIL CONDITIONER

A SOIL CONDITIONER SUCH AS HORTICULTURAL PERLITE, OR AN APPROVED EQUAL SHALL BE USED. THE PARTICLE SIZE GRADATION OF THE SOIL CONDITIONER SHALL BE AT LEAST 60% PASSING A NO. 6 SIEVE AND NOT MORE THAN 5% PASSING A NO. 50 SIEVE. ALTERNATE SHALL BE "TURFACE", "LUSOIL" OR "TERRAGREEN".

 
## HERBICIDES

AFTER PLANTING AND FERTILIZING HAVE BEEN COMPLETED AND APPROVED, THE AREA OF THE BED SHALL BE TREATED WITH SIMAZINE, DYMID OR AN APPROVED EQUAL HERBICIDE. RATE AND METHOD OF APPLICATION SHALL BE IN STRICT CONFORMANCE WITH MANUFACTURER'S INSTRUCTIONS AND UNDER THE DIRECT SUPERVISION OF A PESTICIDE APPLICATOR LICENSED BY THE STATE OF OHIO.

## INSTALLATION


TREES AND SHRUBS SHALL BE INSTALLED IN ACCORDANCE WITH THIS SHEET AND O.D.O.T. STD. DRWG. LA-2.

|                                                                                                                                                                                                         |                                                    |                        |
|---------------------------------------------------------------------------------------------------------------------------------------------------------------------------------------------------------|----------------------------------------------------|------------------------|
| OHIO DEPARTMENT OF TRANSPORTATION<br>DIVISION OF HIGHWAYS                                                                                                                                               |                                                    | SHEET NO.<br><b>66</b> |
| REVISIONS<br>4-28-83                                                                                                                                                                                    | MOTORIST SERVICES BUILDING<br>AND<br>STORAGE UNITS | DATE                   |
| ARCHITECTS: WRIGHT/KRITSCHGAU, ASSOCIATES, INC.<br>3600 TRABUE RD., COLUMBUS, OHIO<br>ENGINEERS: JOHN E. FOSTER & ASSOCIATES, COLUMBUS, OHIO<br>LANDSCAPE ARCHITECTS: THE HORTICULTURAL SOCIETY OF OHIO |                                                    |                        |




|                                                                                                                                                                                              |                                                             |                       |
|----------------------------------------------------------------------------------------------------------------------------------------------------------------------------------------------|-------------------------------------------------------------|-----------------------|
| OHIO DEPARTMENT OF TRANSPORTATION<br>DIVISION OF HIGHWAYS                                                                                                                                    |                                                             | SHEET NO<br><b>6H</b> |
| REVISIONS<br><b>11-1-84</b>                                                                                                                                                                  | <b>MOTORIST SERVICES BUILDING<br/>AND<br/>STORAGE UNITS</b> | DATE                  |
| ARCHITECTS: WRIGHT & KRITSCHGAU, ASSOCIATE, INC.<br>3600 TRABUE ROAD, CT., CUMBUS, OHIO<br>ENGINEERS: JOHN E. FOSTER & ASSOCIATES, COLUMBUS, OHIO<br>ENERGY TECHNOLOGIES, BATTLE CREEK, OHIO |                                                             |                       |

NOTE: THE COMPLETED ASSEMBLY WILL RECEIVE A 1/4" COAT OF ROOFING TAR OVER ENTIRE ASSEMBLY AND BEARING

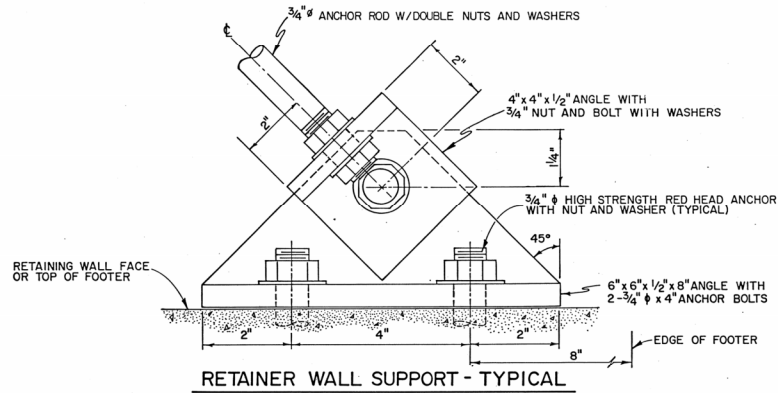


NOT TO SCALE  
6HA-02

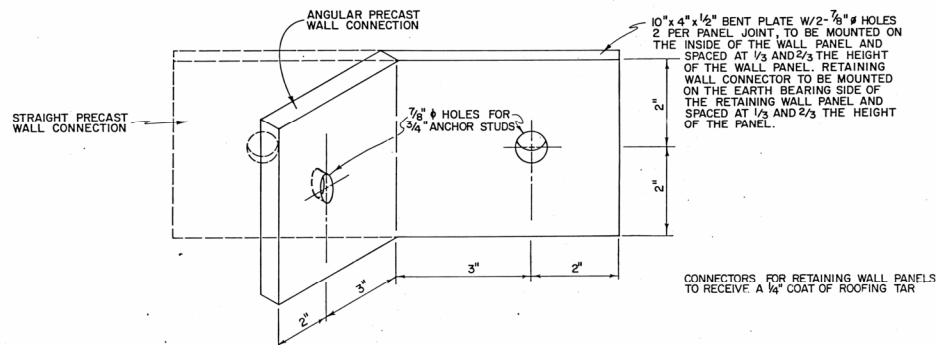


PRECAST WALL BUTT JOINT CONNECTOR-TYPICAL

NOT TO SCALE  
6HA-03

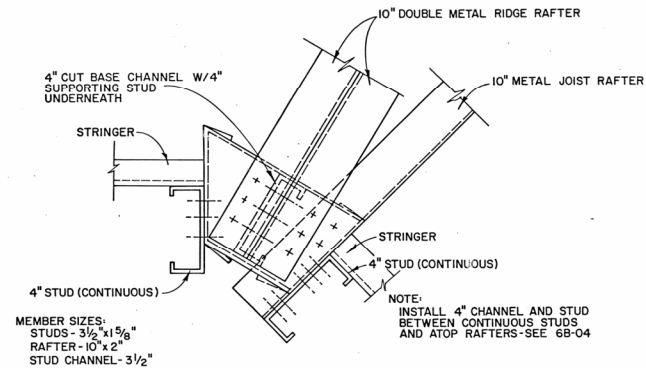


ROOF RAFTER FRAMING PLAN DETAIL-TYPICAL

NOT TO SCALE  
6HA-01

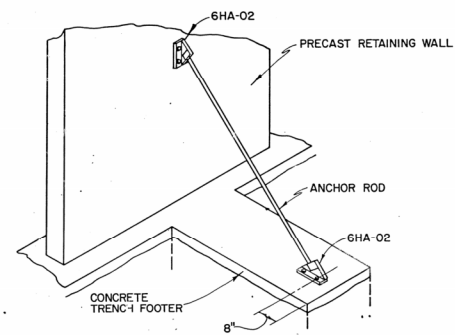

RETAINER WALL SUPPORT ASSEMBLY-TYPICAL

NOT TO SCALE  
6HA-04

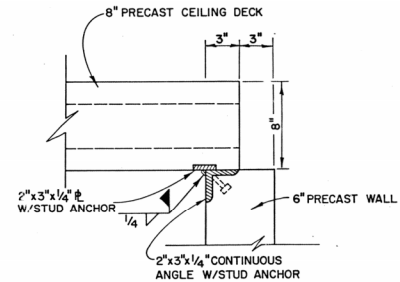

BEARING WALL / PRECAST DECK  
JOINT CONNECTION

NOT TO SCALE  
6HA-05

| OHIO DEPARTMENT OF TRANSPORTATION<br>DIVISION OF HIGHWAYS                                                                                                                                             |                                                    |                  |
|-------------------------------------------------------------------------------------------------------------------------------------------------------------------------------------------------------|----------------------------------------------------|------------------|
| REVISIONS                                                                                                                                                                                             | MOTORIST SERVICES BUILDING<br>AND<br>STORAGE UNITS | SHEET NO.<br>6HA |
| ARCHITECTS: WRIGHT / KRITSCHGAU, ASSOCIATES, INC.<br>3600 TRABUE RD., COLUMBUS, OHIO<br>ENGINEERS: JOHN E. FOSTER & ASSOCIATES, COLUMBUS, OHIO<br>ENERGY TECHNOLOGIES: BATTLE / COLUMBUS LABORATORIES |                                                    | DATE             |

NOTE 1 STEEL LINTELS AT PRECAST CONC. OPENINGS  
WILL BE PROVIDED BY PRECAST FABRICATOR.

NOTE 2 ALL OPENINGS AROUND CEILING PENETRATIONS  
SHALL BE FORMED AND POURED WITH CONCRETE

NOTE 3 ALL WALL OPENINGS WILL HAVE LINTELS OF  
2-#4 BARS EXTENDING 8" BEYOND THE FRAME  
EACH SIDE.


NOTE 4 ALL PRECAST STRUCTURES WILL BE ASSEMBLED  
AS PER MANUFACTURERS INSTRUCTIONS.

NOTE 5 ALL PRECAST CONCRETE CEILING DECK OPENINGS  
WILL BE BY FABRICATOR



NOTE 6 PRECAST CONCRETE DECK WILL BE DESIGNED  
TO SUPPORT A LIVE LOAD OF 52 PSF AT MAXIMUM SPAN

NOTE 7 ALL PRECAST ASSEMBLIES WILL HAVE A MINIMUM 2-HOUR FIRE RATING


NOTE 8 THE BUILDING AS DESIGNED BY THE ARCHITECT AND ENGINEER WAS DESIGNED TO HANDLE A 25 POUND - FORCE PER SQUARE FOOT (PSF) SNOW LOAD.

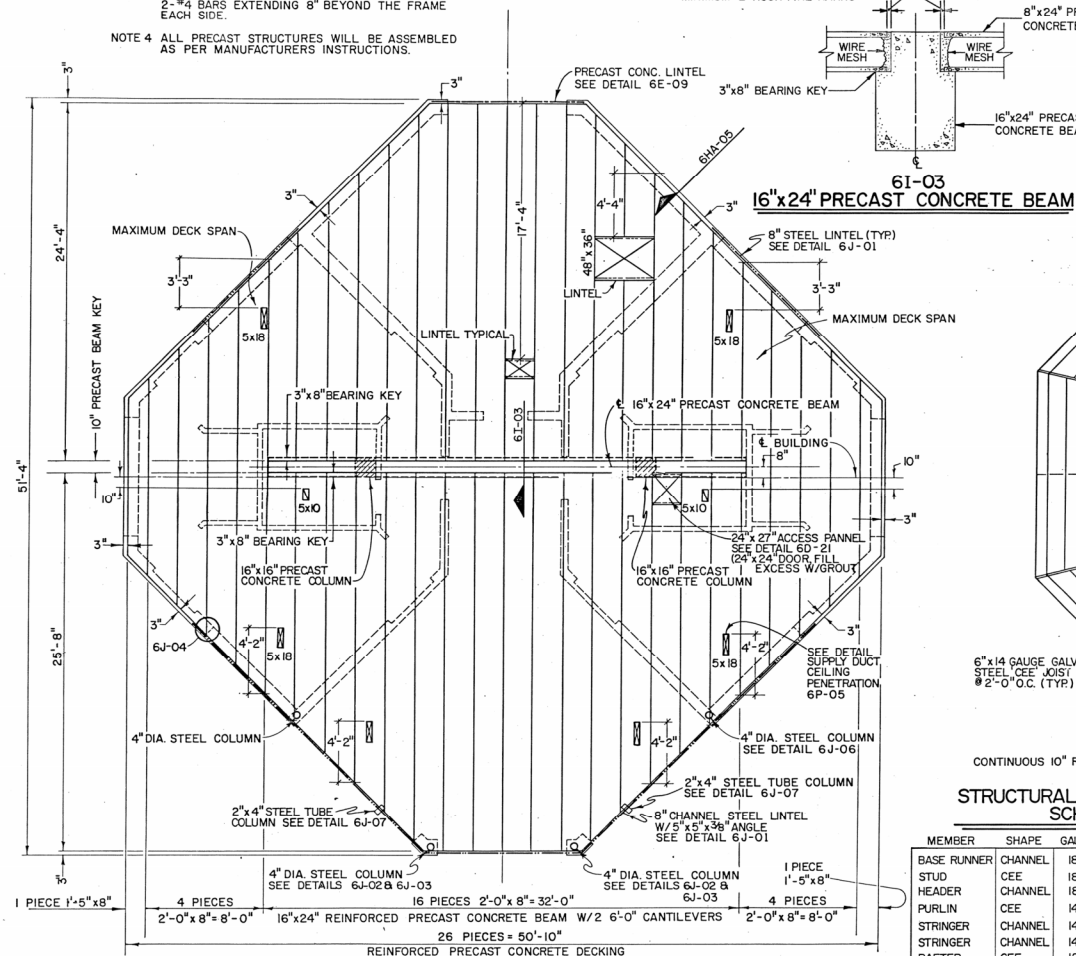

6I-01  
CEILING DECK PLAN

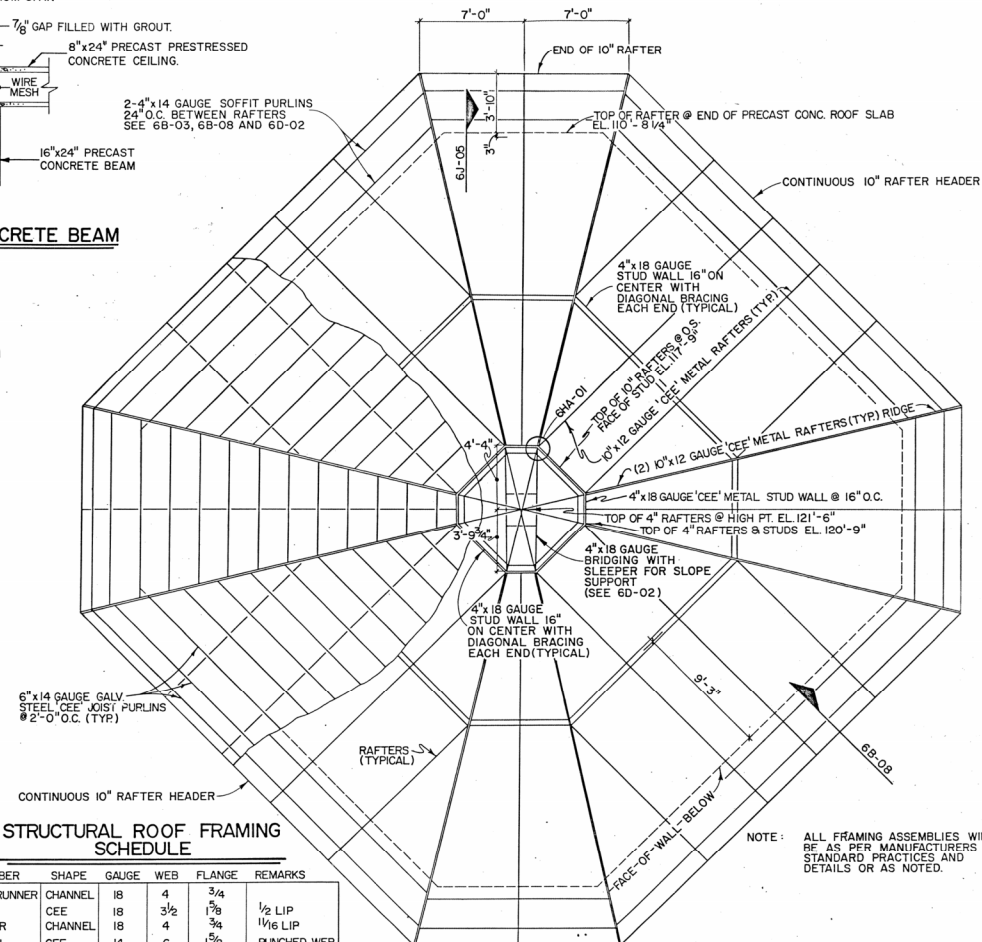 

6 I - 02  
ROOF FRAMING PLAN

 


| MEMBER      | SHAPE   | GAUGE | WEB   | FLANGE | REMARKS    |
|-------------|---------|-------|-------|--------|------------|
| BASE RUNNER | CHANNEL | 18    | 4     | 3/4    |            |
| STUD        | CEE     | 18    | 3 1/2 | 1 5/8  | 1/2 LIP    |
| HEADER      | CHANNEL | 18    | 4     | 3/4    | 1 1/4 LIP  |
| PURLIN      | CEE     | 14    | 6     | 1 5/8  | PUNCHED WE |
| STRINGER    | CHANNEL | 14    | 4     | 1 5/16 |            |
| STRINGER    | CHANNEL | 14    | 10    | 1 3/16 |            |
| RAFTER      | CEE     | 12    | 10    | 2      | 1 1/2 LIP  |
| RAFTER      | CEE     | 14    | 4     | 1 5/8  | PUNCHED WE |
| X-BRACING   |         | 18    |       |        | STRIPS     |

NOTE: ALL METAL FRAMING JOINTS WILL HAVE A MINIMUM OF TWO FASTENERS OR MORE TO ASSURE STABILITY


NOTE: ALL FRAMING ASSEMBLIES WILL  
BE AS PER MANUFACTURERS  
STANDARD PRACTICES AND  
DETAILS OR AS NOTED.

|                                                                                                                                                                                               |                                                    |     |           |
|-----------------------------------------------------------------------------------------------------------------------------------------------------------------------------------------------|----------------------------------------------------|-----|-----------|
| OHIO DEPARTMENT OF TRANSPORTATION<br>DIVISION OF HIGHWAYS                                                                                                                                     |                                                    |     | SHEET NO. |
| REVISIONS<br>4/28/83                                                                                                                                                                          | MOTORIST SERVICES BUILDING<br>AND<br>STORAGE UNITS | 6 I |           |
| ARCHITECTS - WRIGHT / KRITSCHGALL ASSOCIATES, INC.<br>3600 TRABUE RD., COLUMBUS, OHIO<br>ENGINEERS - JOHN E. FOSTER & ASSOCIATES, COLUMBUS, OHIO<br>ENERGY TECHNOLOGIES, INC., COLUMBUS, OHIO |                                                    |     | DATE      |




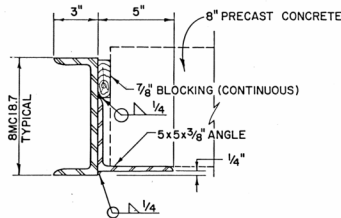


**LINTEL-TYPICAL SECTION**  
NOT TO SCALE  
**6J-01**

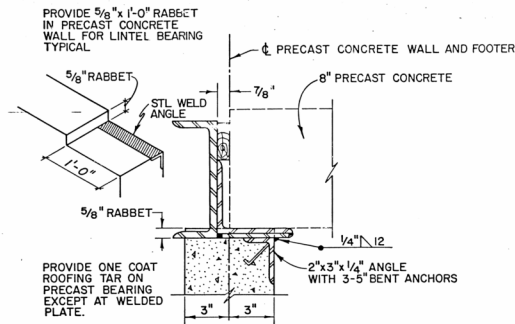


**STEEL LINTEL / PRECAST BEARING DETAIL-TYPICAL**  
NOT TO SCALE  
**6J-04**

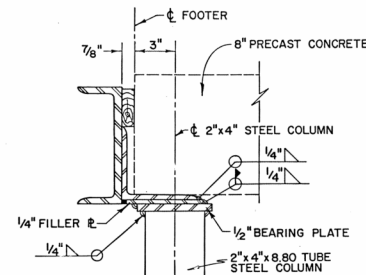


**2"x4" COLUMN CAPITOL ASSEMBLY-TYPICAL**  
NOT TO SCALE  
**6J-07**

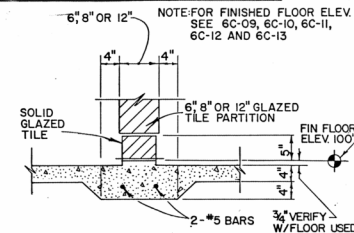


**6' 8" OR 12' GLAZED TILE WALL FOOTER-TYPICAL**  
NOT TO SCALE  
**6J-10**

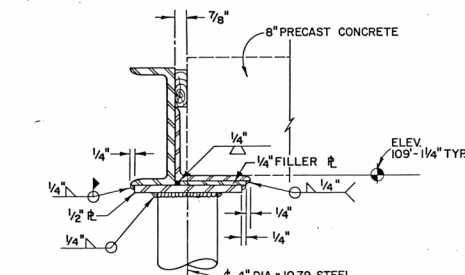


**COLUMN CAPITOL ASSEMBLY-TYPICAL**  
NOT TO SCALE  
**6J-02**

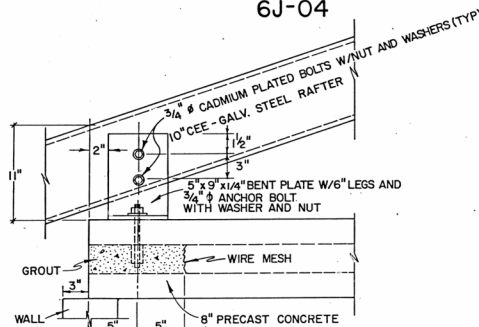


**RAFTER / WALL DETAIL-TYPICAL**  
NOT TO SCALE  
**6J-05**

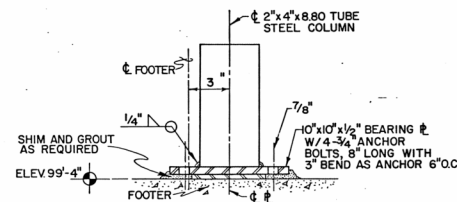


**2"x4" COLUMN BEARING PLATE ASSEMBLY-TYPICAL**  
NOT TO SCALE  
**6J-08**

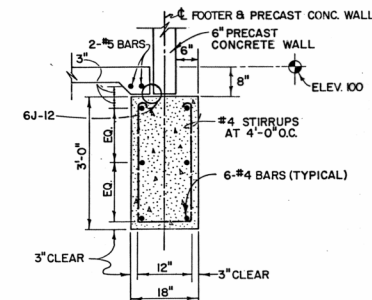


**EXTERIOR WALL FOOTING-TYPICAL**  
NOT TO SCALE  
**6J-11**

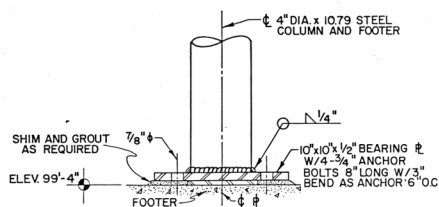


**COLUMN BEARING PLATE ASSEMBLY-TYPICAL**  
NOT TO SCALE  
**6J-03**

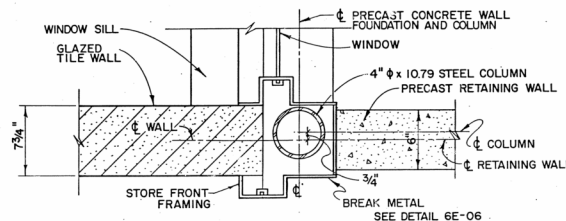

**COLUMN / WALL DETAIL-TYPICAL**  
NOT TO SCALE  
**6J-06**

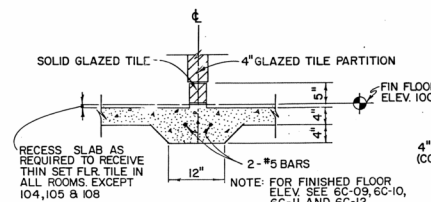

**4' GLAZED TILE WALL FOOTER-TYPICAL**  
NOT TO SCALE  
**6J-09**

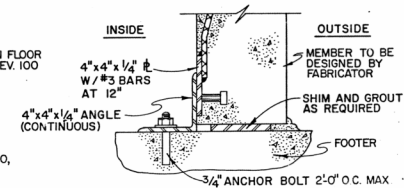

**PRECAST CONCRETE WALL BASE DETAIL**  
NOT TO SCALE  
**6J-12**


NOTE: PROVIDE A COATING OF ROOFING TAR BETWEEN ALL STEEL TO PRE-CAST JOINTS AND BEARING POINTS UNLESS OTHERWISE NOTED

**STRUCTURAL DETAILS**  
NOT TO SCALE


| OHIO DEPARTMENT OF TRANSPORTATION<br>DIVISION OF HIGHWAYS                                                                                                                                                    |                                              |              |
|--------------------------------------------------------------------------------------------------------------------------------------------------------------------------------------------------------------|----------------------------------------------|--------------|
| REVISIONS                                                                                                                                                                                                    | MOTORIST SERVICES BUILDING AND STORAGE UNITS | SHEET NO. 6J |
| ARCHITECTS: WRIGGITT / KRITSCHGAU ASSOCIATES, INC.<br>3600 FRABUE RD., COLUMBUS, OHIO<br>ENGINEERS: JOHN E. FOSTER & ASSOCIATES, COLUMBUS, OHIO<br>ENVIRONMENTAL TECHNOLOGIES BATTLE / COLUMBUS LABORATORIES |                                              | DATE         |



NOT TO SCALE

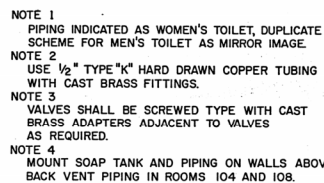

NOT TO SCALE

 

|                                                                                                                                                                                         |                                                    |  |                        |
|-----------------------------------------------------------------------------------------------------------------------------------------------------------------------------------------|----------------------------------------------------|--|------------------------|
| OHIO DEPARTMENT OF TRANSPORTATION<br>DIVISION OF HIGHWAYS                                                                                                                               |                                                    |  |                        |
| REVISIONS<br>10-19-84                                                                                                                                                                   | MOTORIST SERVICES BUILDING<br>AND<br>STORAGE UNITS |  | SHEET NO.<br><b>6K</b> |
| ARCHITECTS: WRIGHT & KRITSCHGAW, ASSOCIATES, INC.<br>3600 TRABUE RD., COLUMBUS, OHIO<br>ENGINEERS: JOHN E. FOSTER & ASSOCIATES, COLUMBUS, OHIO<br>ENERGY: TERNING CORP., COLUMBUS, OHIO |                                                    |  | DATE                   |


MED-71-22.14(5-B)

OHIO  
FHWA  
REGION 5

32  
47


TWO (2) COMPOUND GAUGES,  
30"-0 TO 60 PSI, W/ PRESSURE  
SNUBBER, PIG TAIL, TEE HANDLE  
COCK & LOWER CONNECTION.

SHOCK ABSORBERS (TYPICAL)

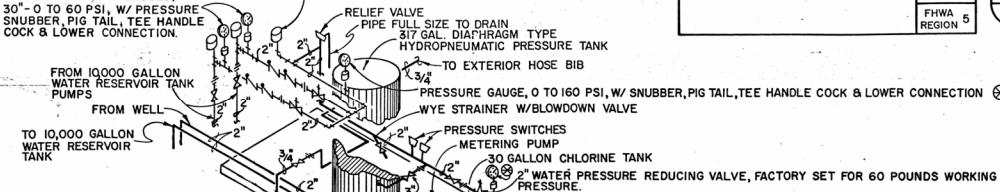

### 6L-02 WELL WATER SERVICE CONNECTION WITH CHLORINATION SYSTEM


NOT TO SCALE

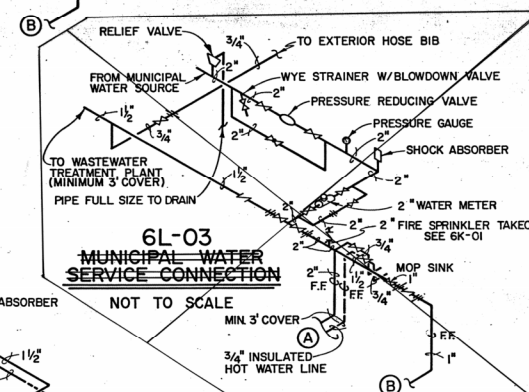

### 6L-03 MUNICIPAL WATER SERVICE CONNECTION

NOT TO SCALE

VOID - SEE DETAIL 6L-02

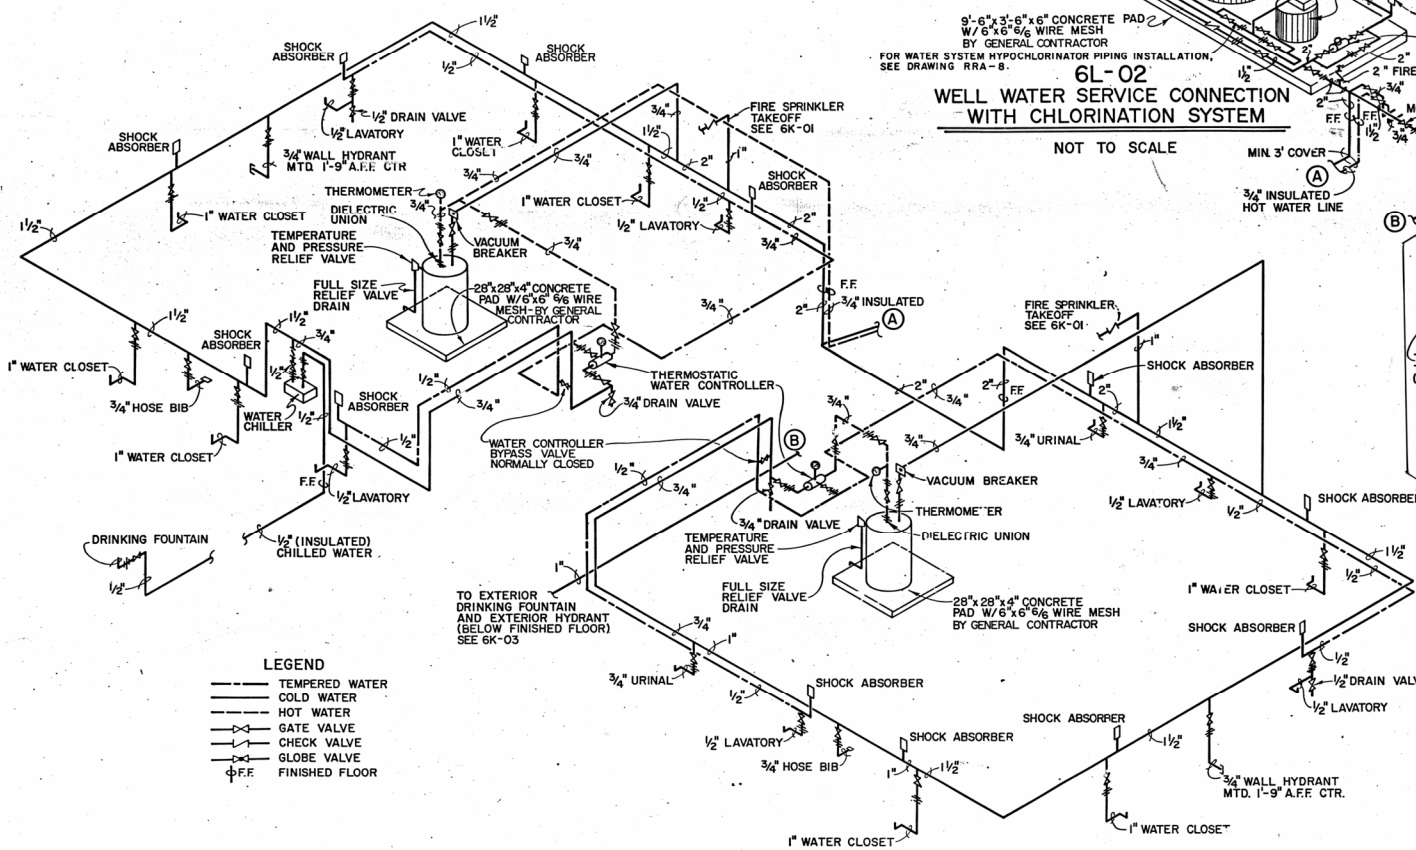


### LEGEND

- TEMPERED WATER
- COLD WATER
- HOT WATER
- GATE VALVE
- CHECK VALVE
- GLOBE VALVE
- F.F.F. FINISHED FLOOR

### 6L-01 POTABLE WATER ISOMETRIC


NOT TO SCALE

| OHIO DEPARTMENT OF TRANSPORTATION<br>DIVISION OF HIGHWAYS                                                                                                                                       |                                                    |                  |
|-------------------------------------------------------------------------------------------------------------------------------------------------------------------------------------------------|----------------------------------------------------|------------------|
| REVISIONS<br>10-19-84<br>11-2-84                                                                                                                                                                | MOTORIST SERVICES BUILDING<br>AND<br>STORAGE UNITS | SHEET NO.<br>6 L |
| ARCHITECTS: WRIGHT / KRITSCHAU, ASSOCIATES, INC.<br>3600 TRAPUE RD., COLUMBUS, OHIO<br>ENGINEERS: JOHN E. F. STETSON & ASSOCIATES, INC.<br>ENERGY TECHNOLOGIES BATTELLE / COLUMBUS LABORATORIES |                                                    | DATE             |

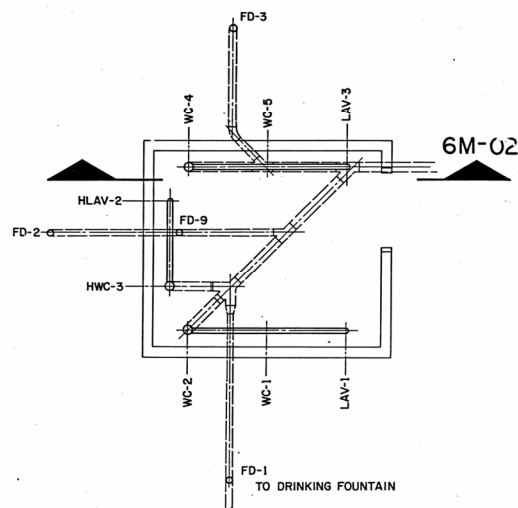


**6M-03**  
**TYPICAL SANITARY PLUMBING PLAN**

NOT TO SCALE

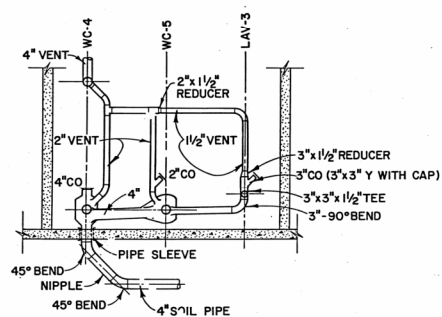

**6M-02**  
**TYPICAL SANITARY PLUMBING SECTION**

NOT TO SCALE

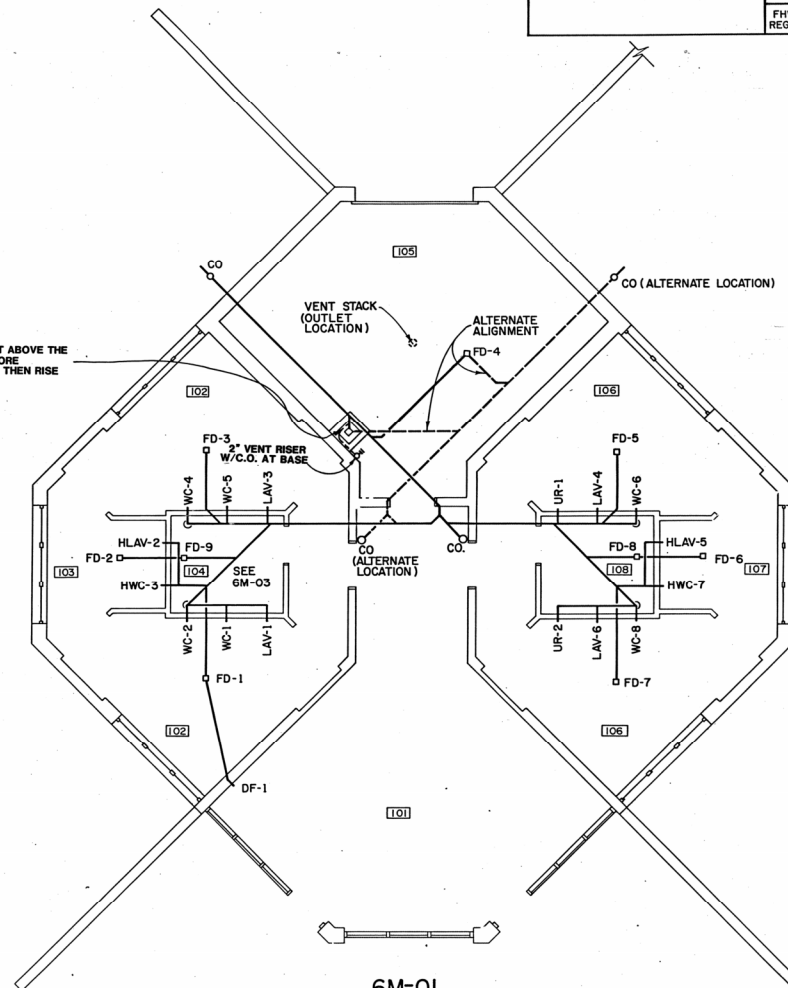


**6M-01**  
**SANITARY PLUMBING PLAN**

0 1 2 4 6 8  
SCALE IN FEET

| OHIO DEPARTMENT OF TRANSPORTATION<br>DIVISION OF HIGHWAYS                                                                                                                                            |                                                    |                 |
|------------------------------------------------------------------------------------------------------------------------------------------------------------------------------------------------------|----------------------------------------------------|-----------------|
| REVISIONS<br>10-8-84                                                                                                                                                                                 | MOTORIST SERVICES BUILDING<br>AND<br>STORAGE UNITS | SHEET NO.<br>6M |
| ARCHITECTS: WRIGHT & KRITSCHGALL ASSOCIATES, INC.<br>3600 TRABUE RD., COLUMBUS, OHIO<br>ENGINEERS: JOHN E. FETER & ASSOCIATES, COLUMBUS, OHIO<br>ENERGY TECHNOLOGIES: BATTELLE/COLUMBUS LABORATORIES |                                                    | DATE            |


- NOTE 1  
ALL LAVATORIES SHALL HAVE 1½" TRAPS.
- NOTE 2  
ALL URINALS SHALL HAVE 2" WASTE OUTLETS.
- NOTE 3  
ALL SOIL, WASTE AND VENT PIPING SHALL BE CAST IRON, NO HUB.
- NOTE 4  
ALL WATER TO HAND WASHING AND BATHING FACILITIES SHALL NOT EXCEED 120°F.

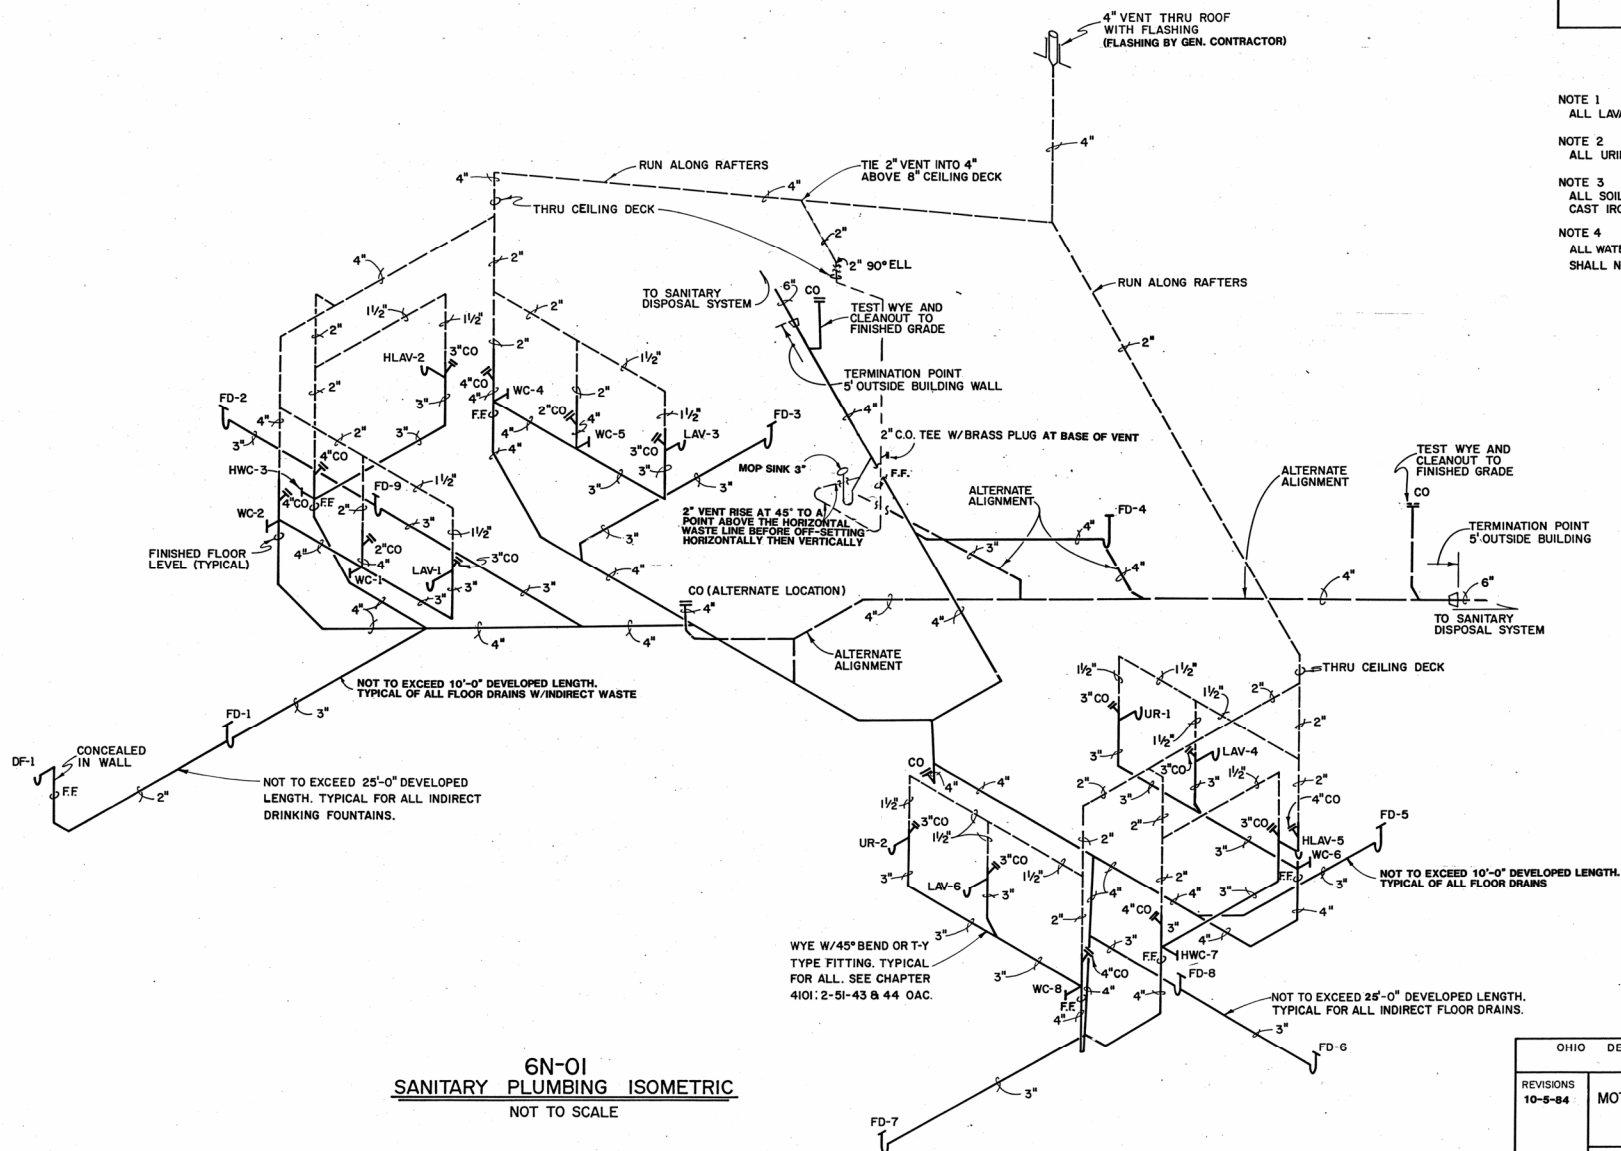OHIO DEPARTMENT OF TRANSPORTATION  
DIVISION OF HIGHWAYSREVISIONS  
10-5-84MOTORIST SERVICES BUILDING  
AND  
STORAGE UNITSSHEET NO.  
6NARCHITECTS: WRIGHT & KRITZSCHAU, ASSOCIATES, INC.  
3600 TRABUE RD., COLUMBUS, OHIO  
ENGINEERS: JOHN E. FOSTER & ASSOCIATES, COLUMBUS, OHIO  
ENERGY TECHNOLOGIES: BATTELLE / COLUMBUS LABORATORIES


DATE







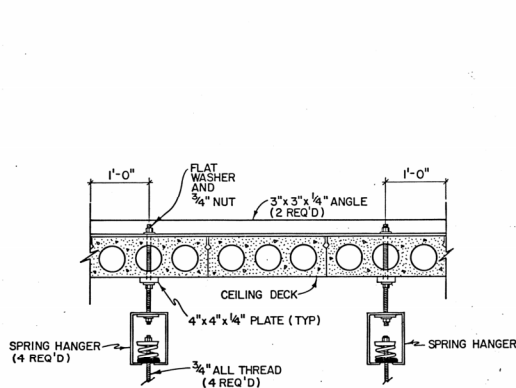


EXHAUST FAN HANGER DETAIL

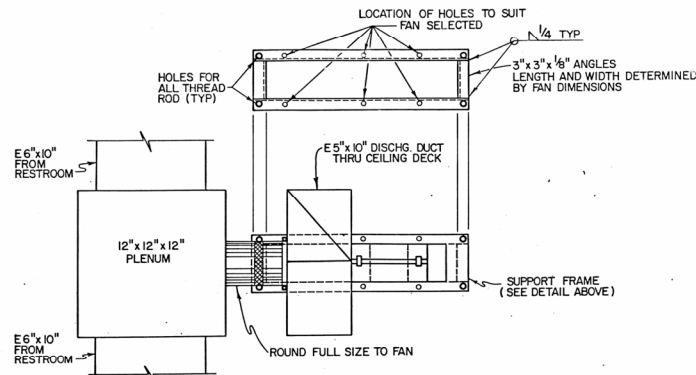NOT TO SCALE  
6P-01

EXHAUST FAN AND SUPPORT FRAME DETAIL

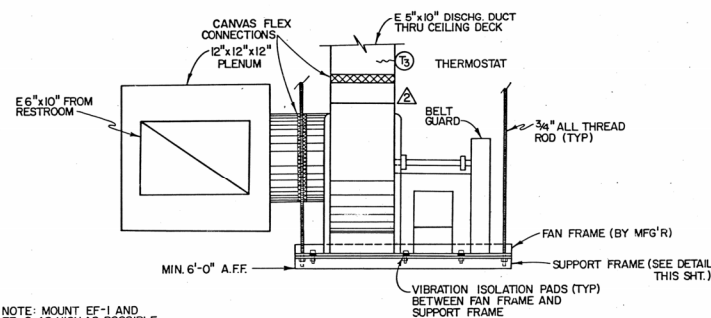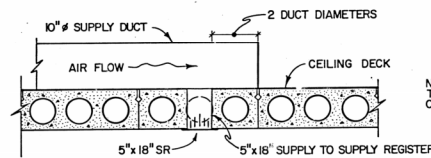NOT TO SCALE  
6P-02NOTE: MOUNT EF-1 AND  
EF-2 AS HIGH AS POSSIBLE-  
6'-0" A.F.F. MIN.ELEVATION  
EXHAUST FAN DETAILNOT TO SCALE  
6P-04

TYPICAL SUPPLY DUCT CEILING PENETRATION

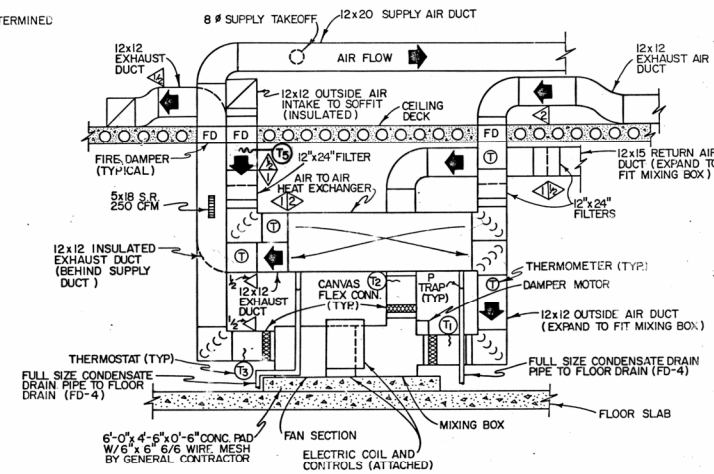NOT TO SCALE  
6P-05

HEATING SYSTEM ELEVATION


6P-03 NOT TO SCALE

- NOTE: 1) MOUNT FAN SECTION, ELECTRIC COIL AND MIXING BOX ON VIBRATION ISOLATORS AS SPECIFIED.  
2) HANG AIR TO AIR HEAT EXCHANGER AS PER MANUFACTURERS RECOMMENDATIONS AND EXHAUST FAN HANGER DETAIL (THIS SHT.)  
3) CEILING DECK VAPOR BARRIER AND INSULATION SHALL BE PLACED OVER THE DUCTWORK  
4) MOUNT AIR TO AIR HEAT EXCHANGER TO DUCT USING COMPANION FLANGES W/BO TS.  
5) EXPAND DUCT AT FILTER SECTIONS TO ACCOMMODATE 12"x24" FILTER. PROVIDE ACCESS DOOR PER SMACNA STANDARDS FOR EACH FILTER.

| OHIO DEPARTMENT OF TRANSPORTATION<br>DIVISION OF HIGHWAYS                                                                                                                                               |                                                    |  |                 |
|---------------------------------------------------------------------------------------------------------------------------------------------------------------------------------------------------------|----------------------------------------------------|--|-----------------|
| REVISIONS<br>1-28-85                                                                                                                                                                                    | MOTORIST SERVICES BUILDING<br>AND<br>STORAGE UNITS |  | SHEET NO.<br>6P |
| ARCHITECTS: WRIGHT / KRITSCHGAU, ASSOCIATES, INC.<br>3600 TRABUE RD., COLUMBUS, OHIO<br>ENGINEERS: JOHN E. FOSTER & ASSOCIATES, COLUMBUS, OHIO<br>ENERGY TECHNOLOGIES: BATTELLE / COLUMBUS LABORATORIES |                                                    |  | DATE            |


## HEATING & VENTILATING AND ELECTRICAL SPECIFICATION REVISIONS

1. UNDER SECTION 14, HEATING AND VENTILATING, PAGE I-64, ITEM 2. AIR HANDLING UNIT, PARAGRAPH (b), DELETE THE FOLLOWING: MOTOR SHALL BE 120 VOLT, 1 PHASE, 60 HERTZ. FAN SHALL HAVE AN ADJUSTABLE V-BELT DRIVE WITH AN EXPANDED METAL BELT GUARD WITH TACHOMETER HOLES. PROVIDE ONE SPARE SET OF V-BELTS. FAN SHALL PROVIDE 1800 CFM @ 1.75 IN. W.G.S.P. INSERT THE FOLLOWING: MOTOR SHALL BE 1 1/2 H.P., 1530 RPM; 120 VOLT, 1 PHASE, 60 HERTZ, FAN SHALL HAVE V-BELT DRIVE UNITS WITH VARIABLE SHEAVES FOR +10%, - 10% ADJUSTMENT WITH AN EXPANDED METAL GUARD WITH TACHOMETER HOLES. PROVIDE ONE SPARE SET OF V-BELTS. FAN SHALL PROVIDE 1800 CFM @ 1.50 IN. W.G.S.P.
2. UNDER SECTION 14, HEATING AND VENTILATING, PAGE I-65, ITEM 3. AIR TO AIR HEAT EXCHANGER, PARAGRAPH (a), DELETE ALL OF PARAGRAPH (a) EXCEPT THE LAST FOUR (4) SENTENCES AND INSERT THE FOLLOWING: (a) FURNISH AND INSTALL AS SHOWN ON THE DRAWINGS ONE (1) FIXED PLATE AIR TO AIR HEAT EXCHANGER. THE HEAT TRANSFER SURFACE SHALL BE A CONTINUOUS SHEET OF DIE FORMED AND FOLDED 1100-1 ALUMINUM THAT CREATES SEPARATE AND DISTINCT AIR FLOW PASSAGES PROVIDING MINIMUM AIR RESISTANCE AND MAXIMUM HEAT TRANSFER. THE DIE FORMED SURFACE SHALL HAVE EMBOSSED RIBS AND HAVE RAISED AND DEPRESSED TRUNCATED CONICAL DIMPLES THAT BEAR ON EACH ADJACENT PLATE, THE DIE FORMING SHALL CREATE ADDITIONAL SURFACE AREA, ENSURE HIGH DIFFERENTIAL PRESSURE CAPABILITY WITHOUT PLATE SURFACE COLLAPSE, AND INCREASE HEAT TRANSFER COEFFICIENTS. THE ENDS OF THE HEAT TRANSFER SURFACE SHALL BE MECHANICALLY SEALED. THE MODULE HOUSING SHALL BE CONSTRUCTED OF 18 GAUGE GALVANEAL STEEL WITH INTEGRAL DOUBLE FLANGED DUCT CONNECTIONS. THE CASING MATERIAL SHALL HAVE PROVISIONS FOR 7 IN. HIGH X 18 IN. WIDTH TRANSITION DUCT CONNECTIONS. THE HEAT EXCHANGER SHALL BE CAPABLE OF 750 SCFM EXHAUST, 800 SCFM SUPPLY, WITH 0.5" W.G.S.P. DROP ACROSS EACH SIDE OF THE HEAT EXCHANGER, WITH 55 DEG. F DRY BULB AND 46 DEG. F WET BULB HOT AIRSTREAM AT A MINIMUM EFFICIENCY OF 65%. AIR FLOW THROUGH THE HEAT EXCHANGER SHALL BE OF THE COUNTERFLOW CONFIGURATION AND BOTH AIR STREAMS SHALL BE HORIZONTAL IN FLOW. THE HEAT EXCHANGER SIZE SHALL BE 22 IN. WIDE X 20 IN. HIGH X 66 IN. LONG. HEAT EXCHANGER SHALL BE MODEL NO. 79ML-1618-.49/.49 AS MANUFACTURED BY DES CHAMPS LABORATORIES, INC. - 2 DUCT. EQUAL HEAT EXCHANGERS AS MANUFACTURED BY UNITED AIR SPECIALISTS, INC. OR APPROVED EQUAL. SHOP DRAWINGS OF SELECTED HEAT EXCHANGER MUST INCLUDE FACTORY THERMODYNAMIC ANALYSIS PRINT READOUTS TO OBTAIN COMPLETE SHOP DRAWING APPROVAL.
3. UNDER SECTION 14, HEATING AND VENTILATING, PAGE I-67, ITEM 5. EXHAUST FANS (EF-1 AND EF-2), PARAGRAPH (a) DELETE ALL OF PARAGRAPH (a) AND INSERT THE FOLLOWING:
  - (a) FURNISH AND INSTALL TWO (2) EXHAUST FANS AS SHOWN ON THE DRAWINGS. FANS SHALL BE MODEL NO. 8B AS MANUFACTURED BY PEERLESS ELECTRIC-PORTER ELECTRICAL DIVISION, H. K. PORTER CO. INC. OR EQUAL FANS MANUFACTURED BY TRANE CO., POWER LINE FANS, OR APPROVED EQUAL. FANS SHALL HAVE V-BELT DRIVE UNITS WITH VARIABLE SHEAVES FOR +15%, - 10% ADJUSTMENT, UTILITY SET TYPE WITH FORWARD CURVED WHEEL. PROVIDE BELT GUARD, COMPLETE DRIVE ASSEMBLY AND FAN AS A PACKAGE UNIT. FAN SHALL BE RATED IN ACCORDANCE WITH AMCA STANDARD 210. MOTORS SHALL BE 1/4 H.P., 120 VOLT, 1-PHASE, 60 HERTZ, TWO (2) SPEED TYPE. EACH FAN SHALL PROVIDE 375 CFM @ 0.875 IN. (7/8") W.G.S.P., 1430 RPM (HI-SPEED) AND 240 CFM @ 0.40 IN. W.G.S.P. (LO-SPEED). PROVIDE ONE SPARE SET OF V-BELTS.
4. UNDER SECTION 15 ELECTRICAL, ITEM 28. SECURITY ALARM SYSTEM, PAGE I-84, PARAGRAPH (d) 1), DELETE AGASTAT MODEL DEL-R-12 OR APPROVED EQUAL. INSERT THE FOLLOWING: AGASTAT TIMING RELAYS 7000 SERIES, MODEL NO. 7012-AKL, OR APPROVED EQUAL. DELETE 10 SECONDS TO 3 1/2 MINUTES AND INSERT 1 TO 300 SECONDS.
5. UNDER SECTION 15 ELECTRICAL, ITEM 28, SECURITY ALARM SYSTEM, PAGE I-84, PARAGRAPH (d) 2), DELETE AGASTAT MODEL DE-R-22. INSERT THE FOLLOWING: AGASTAT TIMING RELAYS 7000 SERIES, MODEL NO. 7022-AK, OR APPROVED EQUAL.

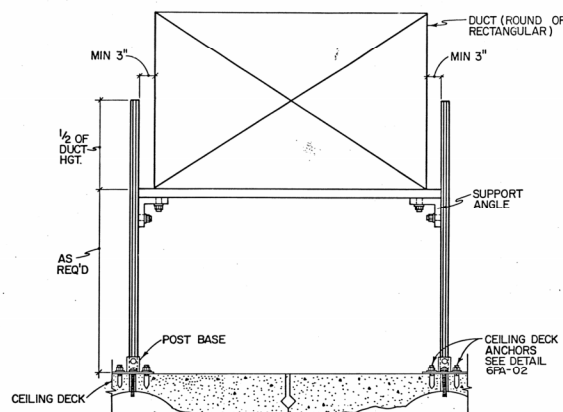

TYPICAL DUCT SUPPORT DETAIL


NOT TO SCALE  
6PA-01

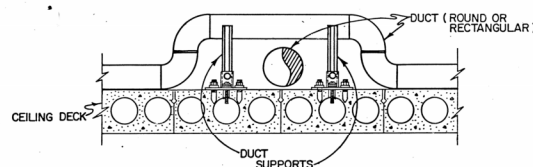


TYPICAL DUCT INTERSECTION SUPPORT DETAIL

NOT TO SCALE  
6PA-03

- NOTE: 1) CEILING DECK INSULATION SHALL BE PLACED OVER ALL DUCT WORK
- 2) WHENEVER POSSIBLE REST DUCT DIRECTLY ON CEILING DECK.
  - 3) PROVIDE DUCT SUPPORTS EVERY 8'-0" ON DUCTS THAT DO NOT REST ON CEILING DECK
  - 4) PROVIDE DUCT SUPPORTS AS DETAILED FOR INTERSECTING DUCTS

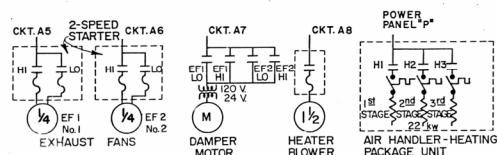


H &amp; V POWER DIAGRAM 6PA-05

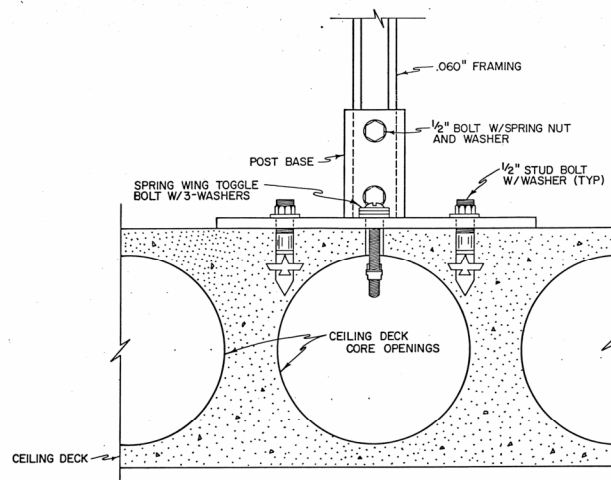


TYPICAL CEILING DECK ANCHOR DETAIL

NOT TO SCALE  
6PA-02

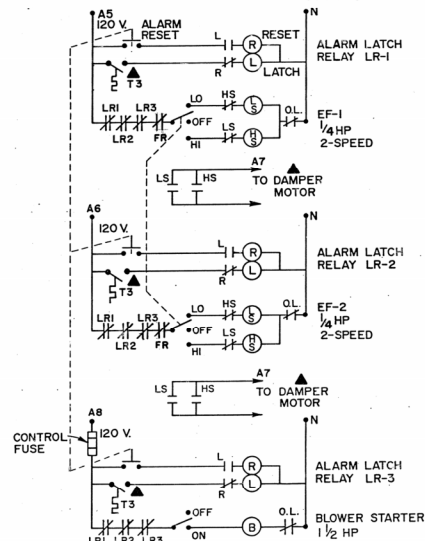

NOTE: 1) HEAT-VENT CONTROL PANEL FURNISHED  
UNDER ELECTRICAL WORK

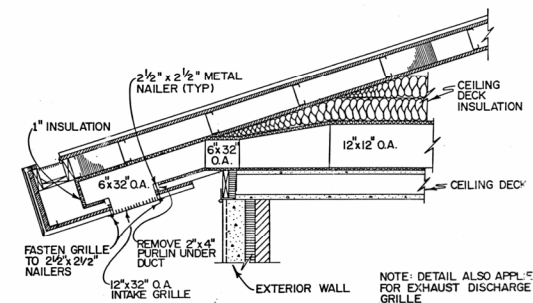

OUTSIDE AIR INTAKE DETAIL


NOT TO SCALE  
6PA-04

- LABEL SHALL READ  
 "EXHAUST FANS OFF-  
 O. A. DAMPER CLOSED."
- NOT TO SCALE  
 6PA-04
- PILOT LIGHT (RED)  
 LOCATE IN THE OUTSIDE AIR DUCT.  
 (UPSTREAM OF THE HEAT EXCHANGER)
- T<sub>5</sub>  
 (FR)  
 FROST RELAY (N.C.)
- HONEYWELL CAT. NO. T631A1029, LINE VOLTAGE  
 SPDT STAT. W/ 8" 0-1" CAPILLARY, -30°F TO 90°F  
 RANGE, 3" F. DIFFERENTIAL OR APPROXIMATELY  
 EQUAL MANIFOLDINGS, REFER TO SPECIFICATION

## AUTOMATIC FROST CONTROL

NOT TO SCALE  
6PA-07

- TO AUTOMATICALLY PREVENT FROST PROBLEMS IN THE HEAT EXCHANGER, WHEN THE TEMPERATURE OF THE OUTSIDE AIR REACHES APPROXIMATELY 10°F AT THE HEAT EXCHANGER, THE LINE VOLTAGE THERMOSTAT SHALL OPEN THE RETURN AIR DAMPER TO STOP THE RETURN AIR FLOW. THE RETURN AIR DAMPER STOPPING THE EXHAUST FANS AND CLOSING THE OUTSIDE AIR DAMPER. THIS SYSTEM CAN BE OVERRIDDEN BY LOWERING THE THERMOSTAT SETTING OR JUMPING ITS CONTACTS. IN THE OPERATING POSITION, THE THERMOSTAT WILL RETURN AIR TO ENTER THE AIR HANDLING UNIT. WHEN THE EXHAUST AIR TEMPERATURE GOES ABOVE THE CUT OFF SET POINT OF THE THERMOSTAT, THE THERMOSTAT WILL RELAY TO CLOSE AND PUT THE HEATING SYSTEM BACK TO ITS ORIGINAL MODE.

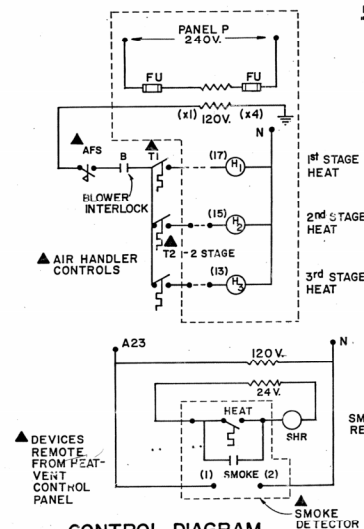

CONTROL DIAGRAM  
HEAT-VENT  
CONTROL PANEL

NOT TO SCALE  
6PA-06


|                                                                                                          |                                                    |           |
|----------------------------------------------------------------------------------------------------------|----------------------------------------------------|-----------|
| OHIO DEPARTMENT OF TRANSPORTATION<br>DIVISION OF HIGHWAYS                                                |                                                    | SHEET NO. |
| REVISIONS<br>1-28-85                                                                                     | MOTORIST SERVICES BUILDING<br>AND<br>STORAGE UNITS | 6 PA      |
| ARCHITECTS: WRIGHTV. KRITSCHGAU, ASSOCIATES, INC.<br>3600 TRABUE RD., COLUMBUS, OHIO                     |                                                    | DATE      |
| ENGINEERS: JOHN E. BROTHER & ASSOCIATES, COLUMBUS, OHIO<br>ENERGY TECHNOLOGIES BATTERMAN, COLUMBUS, OHIO |                                                    |           |

# FIXTURE DEVICE SYMBOL SCHEDULE

| MARK | SYMBOL                                                                            | FIXTURE / DEVICE      | MANUFACTURE - NUMBER        | MOUNTING HEIGHT    | REMARKS                                                                                                                       |
|------|-----------------------------------------------------------------------------------|-----------------------|-----------------------------|--------------------|-------------------------------------------------------------------------------------------------------------------------------|
| A    |  | FLUSH UP LITE         | HYDREL 6062 MV 175/240 HPF  | FLUSH AT GRADE     | W/611 AND .6174, SEE NOTE 175 W. MV.                                                                                          |
| B    |  | RECESS-SOFFIT LITE    | MARCO HN 633404/06/35S240   | SOFFIT             | VANDAL RESIS. ANT. 3 150W HI 3-55 VOLT LAMP                                                                                   |
| C    |  | SURFACE-CEILING LITE  | MARCO LN 708004/35/40 D 240 | 9'-1"              | 175 W. MH.                                                                                                                    |
| D    |  | FLUORESCENT LITE      | LITHONIA WA 240 A           | 9'-1"              | 2-40 WATT, WATT-MISER II 8 ENERGY SAVING BALLAST                                                                              |
| E    |  | FLUORESCENT LITE      | KENALL 7170-DW-9518         | 8'-1"              | 1-40 WATT, WATT-MISER II 8 ENERGY SAVING BALLAST                                                                              |
| F    |  | FLAGPOLE UP/DN        | NL DK-1210/175/LTFP-240 V.  | 10'-0" AFG         | 2 REQ'D. R-40 LAMP                                                                                                            |
|      |  | SWITCH - 3 WAY        |                             | 4'-6" AFF          | SURFACE MOUNTED                                                                                                               |
|      |  | SWITCH- RAISE/LOWER   |                             | 4'-6" AFF          |                                                                                                                               |
| G    |  | EXIT LIGHTS           | KENALL 6590 GW-EM           | CEILING            | 2-20W-T6 1/2, GREEN ON WHITE W/ TUNGSTEN HALOGEN EMERGENCY LIGHT PACK (PROVIDES 90 MINUTES OF LIGHT AFTER POWER INTERRUPTION) |
|      |  | DUPLEX RECEPTACLE     |                             | 2'-0" AFF          |                                                                                                                               |
|      |  | JUNCTION BOX          |                             |                    |                                                                                                                               |
|      |  | TELEPHONE OUTLET      |                             | 4'-6" AFF.         | HANDICAPPED 30" AFF                                                                                                           |
|      |  | DOOR SECURITY SWITCH  |                             |                    |                                                                                                                               |
|      |  | SMOKE & HEAT DETECTOR |                             | CEILING            |                                                                                                                               |
|      | ----                                                                              | CONDUIT- UNDERGROUND  |                             |                    |                                                                                                                               |
|      | ----                                                                              | CONDUIT- SURFACE      |                             |                    |                                                                                                                               |
|      | ----                                                                              | CONDUIT- OVERHEAD     |                             | ABOVE CEILING DECK |                                                                                                                               |


ABOVE CEILING DECK

SQUARE "D" HEAVY DUTY SAFETY SWITCH, 3-WIRE S/N (2 BLADE 2 FUSES) 240 VOLT A.C. NEMA 12, CAT. NO. H221NAWK OR EQUAL W/ CLASS R REJECTION KIT. FUSE W/ C/L TYPE FUSES SHANNUT A2K-20, CLASS R OR EQUAL. FURNISH W/ PAD LOCK & 10 KEYS, KEYED ALIKE. IDENTIFY, "EXIT LIGHTS ONLY."

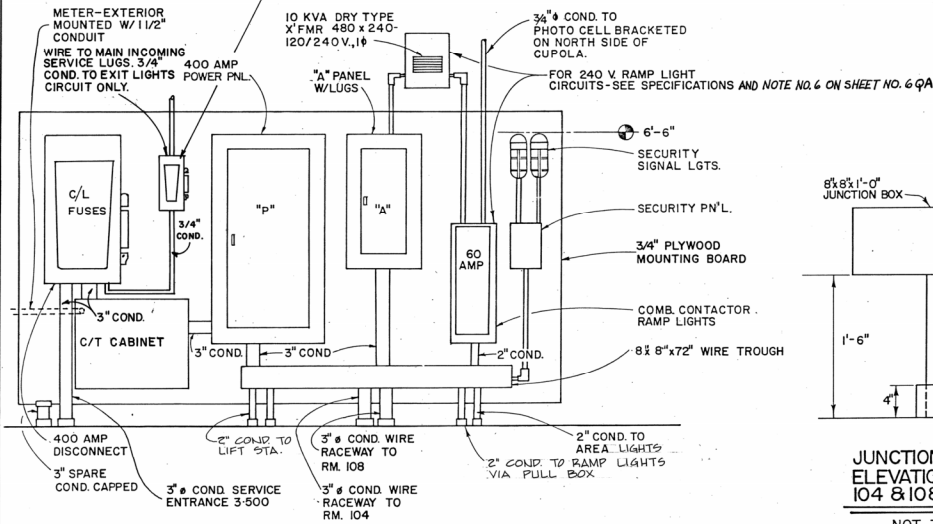


ELECTRICAL PANEL ELEVATION

NOT TO SCALE  
6Q-01

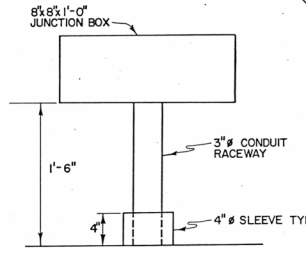


JUNCTION BOX ELEVATION ROOMS 104 & 108 (TYP)

NOT TO SCALE  
6Q-02

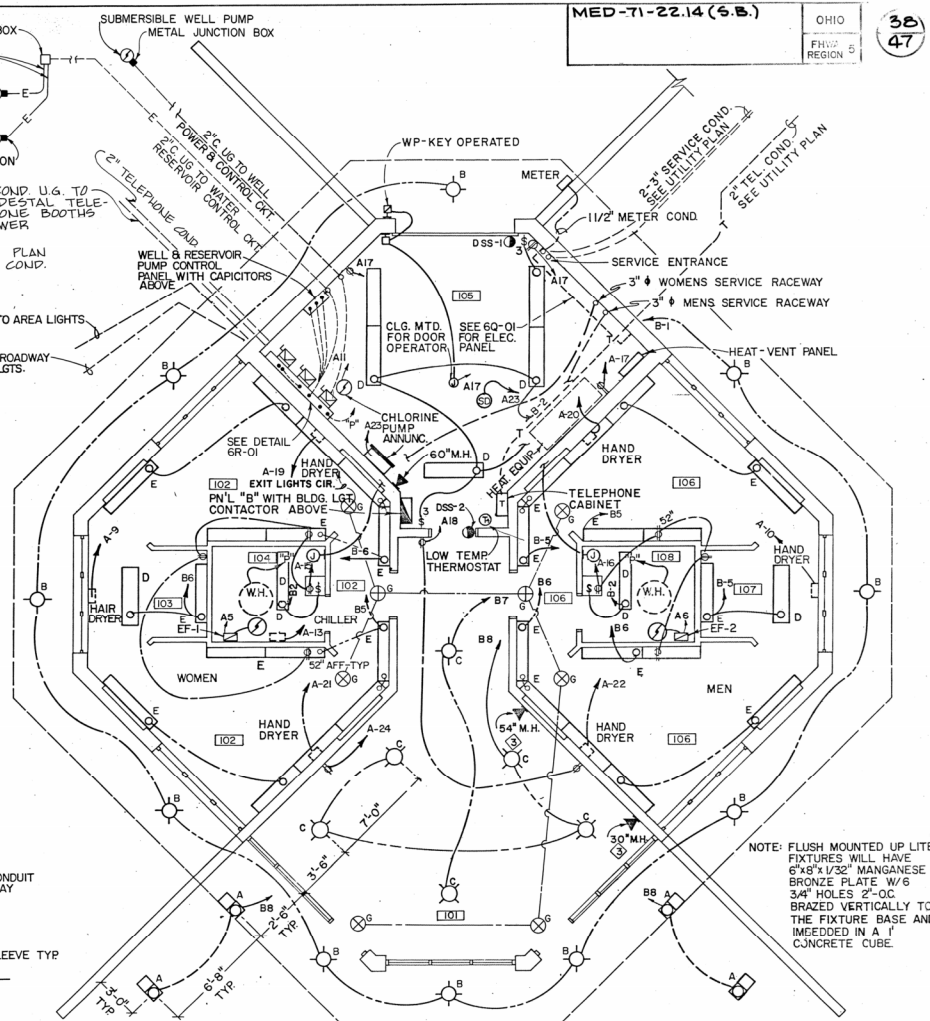

6Q-03  
LIGHTING PLAN

SCALE IN FEET  
0 1 2 4 6 8

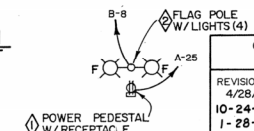

MED-71-22.14 (S.B.)

OHIO  
FHVZ  
REGION 5

38  
47

| REVISIONS | DATE | DESCRIPTION | SHEET NO |
|-----------|------|-------------|----------|
| 4/28/83   |      |             | 6 Q      |
| 10-24-84  |      |             |          |
| 1-28-85   |      |             |          |

OHIO DEPARTMENT OF TRANSPORTATION  
DIVISION OF HIGHWAYS  
MOTORIST SERVICES BUILDING AND STORAGE UNITS

ARCHITECTS: WRIGHT KRITZCHAU ASSOCIATES, INC.  
3600 TRABUE RD., COLUMBUS, OHIO  
ENGINEERS: JOHN E. FOSTER & ASSOCIATES, COLUMBUS, OHIO  
ENERGY TECHNOLOGIES BATTTEL/COLUMBUS LABORATORIES

DATE